


NOTE: ELEVATION VIEWED FROM THE OUTSIDE LOOKING IN.

JRATIO	N:			тм	COMFORT L	INE LTD.	
TIO DOOR		Cor	me	5500 ENTERPRISE BLVD.			
			LASS WINDOWS, PATIO DOORS, SU	JNROOMS & STOREFRONT	TOLEDO, OF 419-729-852		
RAWING			AWING IS THE F				
		DESIGN CONCEPTS AND INFORMATION MAY NOT BE					
		REPRODUCED USED OR DISCLOSED WITHOUT THE WRITTEN					
		PERMISS	ION OF COMFO	RT LINE LTD.			
				PROJECT:			
		SCALE:	6" = 1' - 0"		5000 PAT	IO DOOR	
		DATE:	2/13/17	QUOTE:	####	SHEET: DD4 4	
N	BY	DRAWN BY:	AJL			PD1.1	

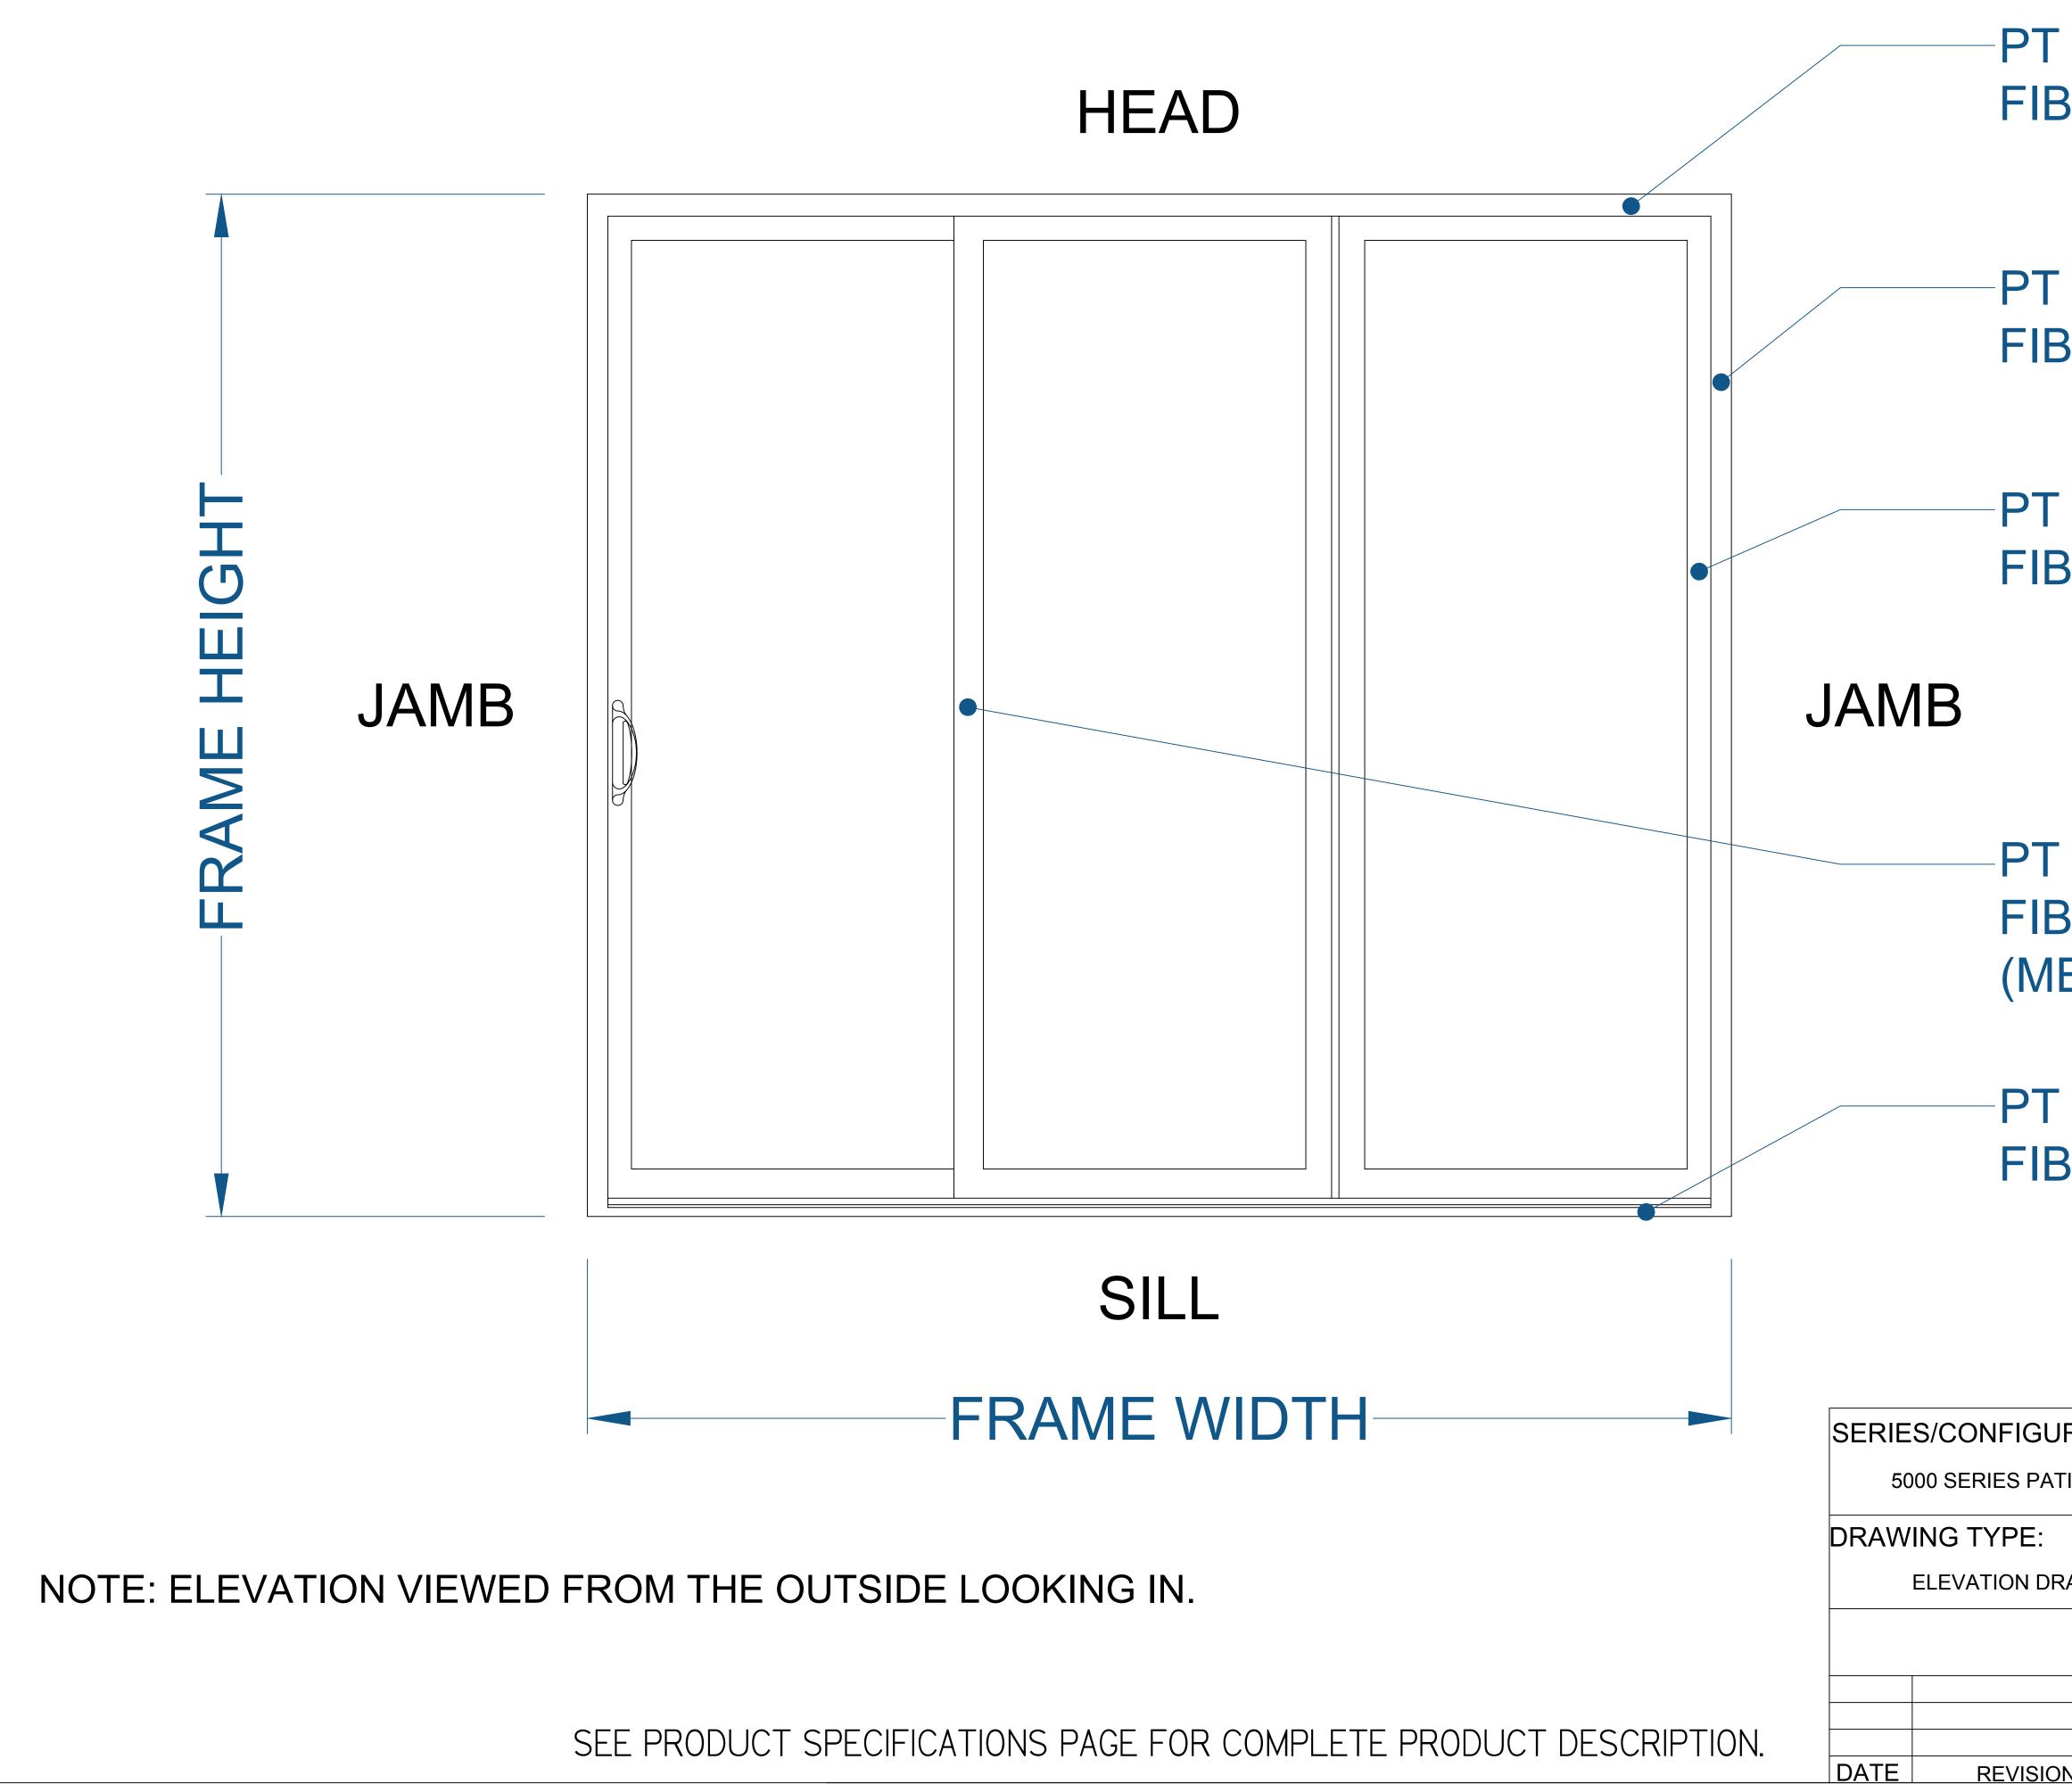

5000 SERIES PATIO DOOR - 3 LITE (CONTINUOUS) (ELEVATION DRAWING)

-PT 5009 TYP. FIBERGLASS FRAME


-PT 5008 TYP. FIBERGLASS FRAME

-PT 5004 TYP. FIBERGLASS SASH

-PT 5005 TYP. FIBERGLASS SASH (MEETING RAIL)

-PT 5010 TYP. FIBERGLASS FRAME

RATION	N:			ТМ	COMFORT L	.INE LTD.
TIO DOOR		Com	DEFFT fort Line® ASS WINDOWS, PATIO DOORS, S		5500 ENTER TOLEDO, OF	RPRISE BLVD. H 43612
					419-729-852	0
RAWING		THIS DRA	AWING IS THE I	PROPERTY O	F COMFORT L	INE LTD.
		DESIGN CONCEPTS AND INFORMATION MAY NOT BE				
			ICED USED OR ON OF COMFO		WITHOUT THE	WRITTEN
				PROJECT:		
		SCALE:	6" = 1' - 0"		5000 PAT	
		DATE:	2/13/17	QUOTE:	####	SHEET: DD1 2
Ν	BY	DRAWN BY:	AJL		ππππ	PD1.2

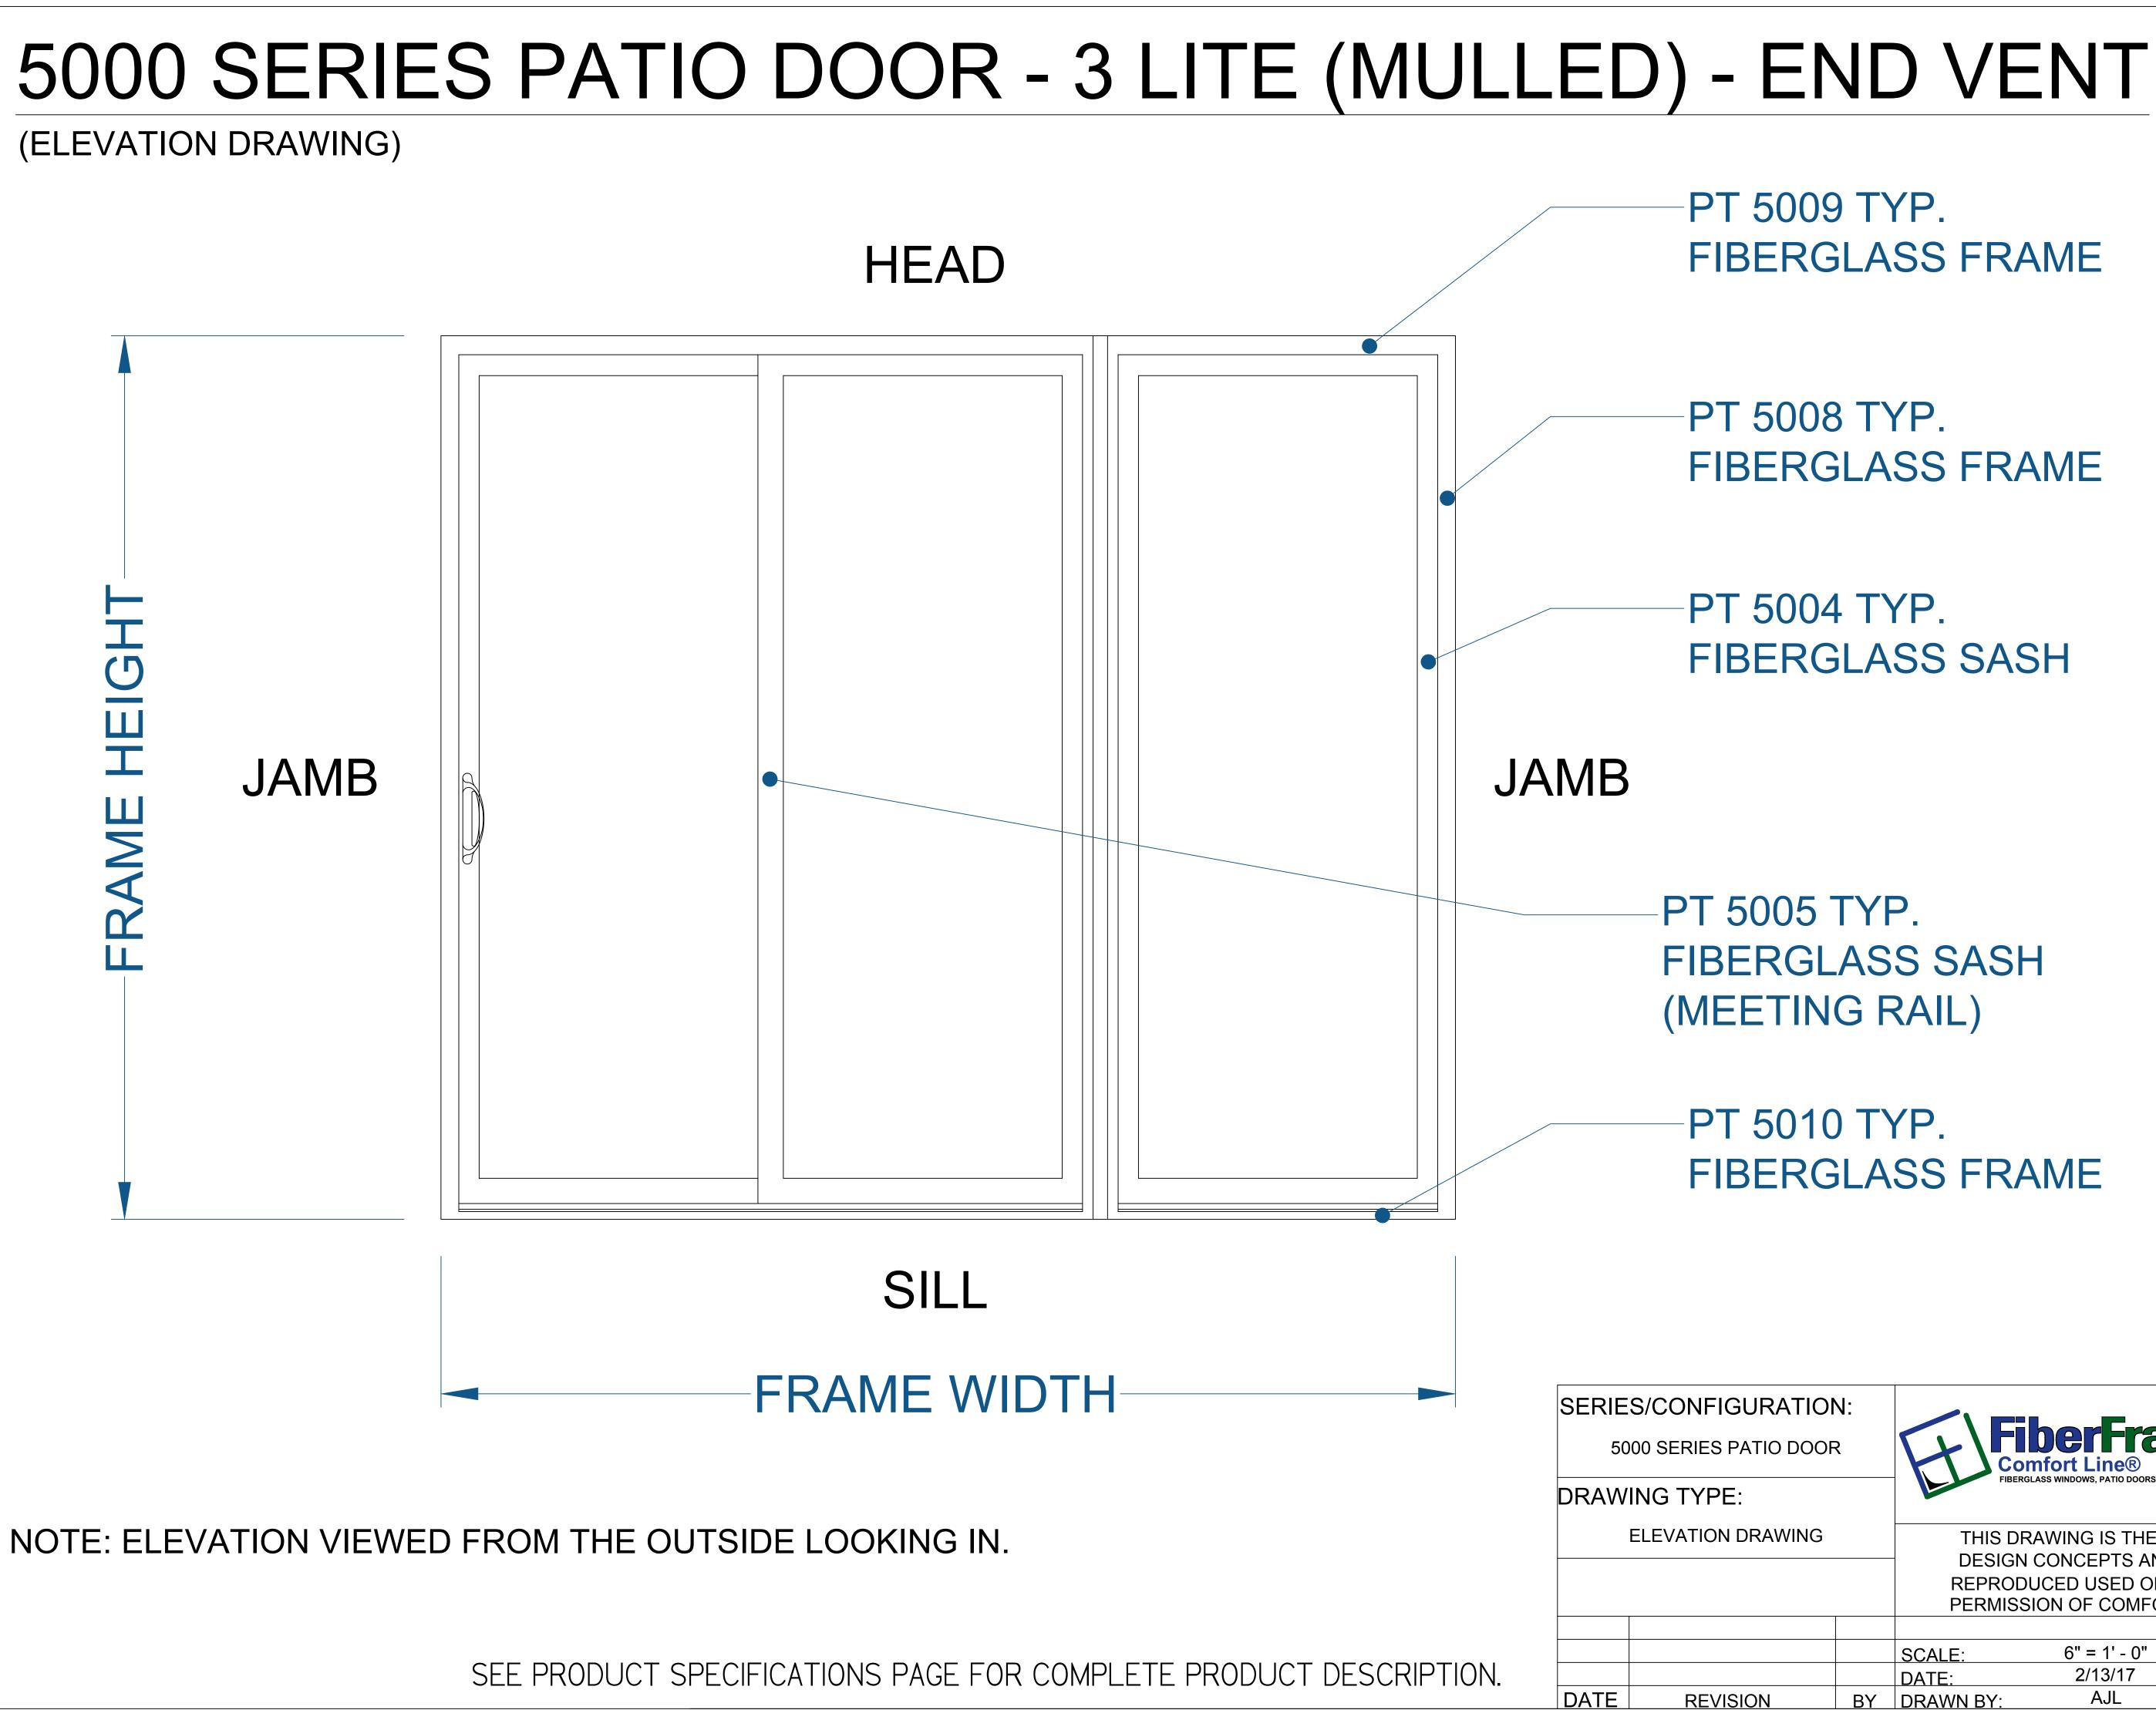

PT 5009 TYP. FIBERGLASS FRAME


PT 5008 TYP. FIBERGLASS FRAME

-PT 5004 TYP. FIBERGLASS SASH

PT 5005 TYP. FIBERGLASS SASH (MEETING RAIL)

PT 5010 TYP. FIBERGLASS FRAME

RATION:			тм	COMFORT L	INE LTD.	
TIO DOOR		berFra	me	5500 ENTERPRISE BLVD.		
		LASS WINDOWS, PATIO DOORS, SU	INROOMS & STOREFRONT	TOLEDO, OF 419-729-852		
RAWING		AWING IS THE F				
	- DESIGN	DESIGN CONCEPTS AND INFORMATION MAY NOT BE				
	REPRODUCED USED OR DISCLOSED WITHOUT THE WRITTEN					
	PERMISS	ION OF COMFOR	RT LINE LTD.			
			PROJECT:			
	SCALE:	6" = 1' - 0"		5000 PAT	IU DUUR	
	DATE:	2/13/17	QUOTE:	####	SHEET: DD4 2	
N BY	DRAWN BY:	AJL			PD1.3	

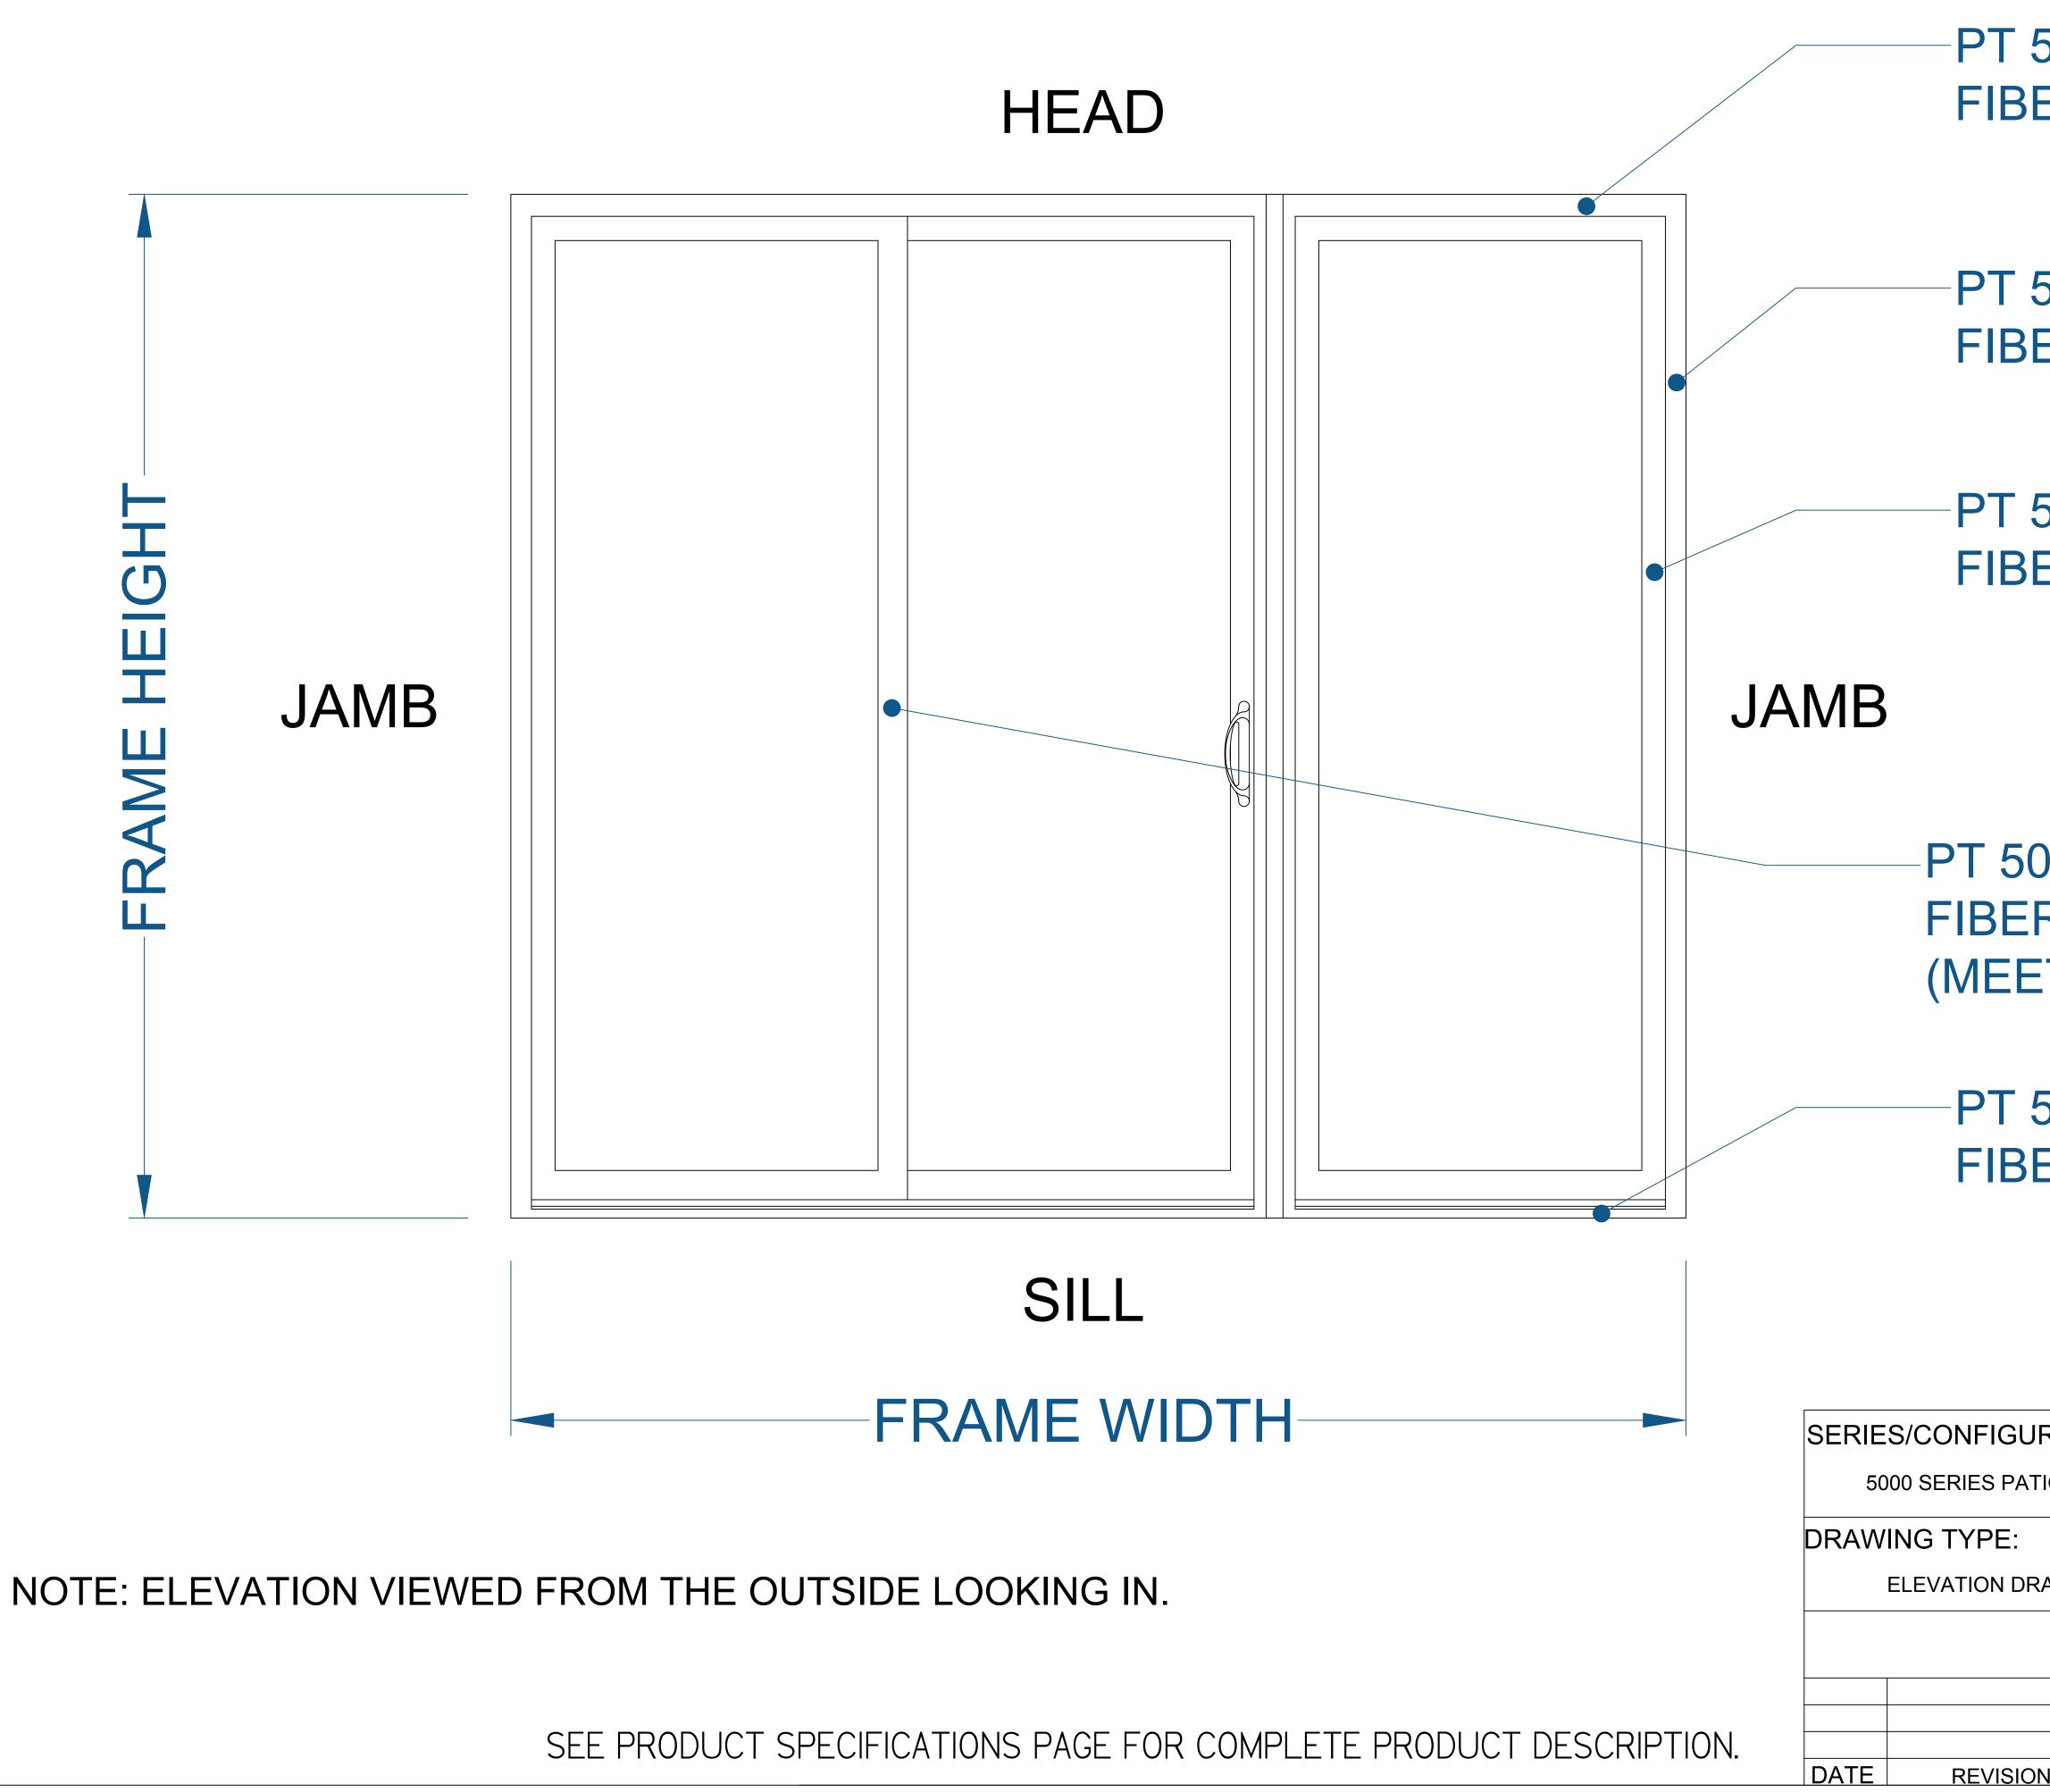



PT 5009 TYP. FIBERGLASS FRAME


PT 5008 TYP. FIBERGLASS FRAME

PT 5004 TYP. FIBERGLASS SASH

PT 5005 TYP. FIBERGLASS SASH (MEETING RAIL)

PT 5010 TYP. FIBERGLASS FRAME

RATION:				тм	COMFORT L	INE LTD.
TIO DOOR			berFra	me	5500 ENTERPRISE BLVD.	
			LASS WINDOWS, PATIO DOORS, SI	JNROOMS & STOREFRONT	TOLEDO, OF 419-729-852	
RAWING	_		AWING IS THE F			
		DESIGN CONCEPTS AND INFORMATION MAY NOT BE				
		REPRODUCED USED OR DISCLOSED WITHOUT THE WRITTEN				
		PERMISS	ION OF COMFO	RT LINE LTD.		
				PROJECT:	5000 PAT	
		SCALE:	6" = 1' - 0"		5000 PAT	
		DATE:	2/13/17	QUOTE:	<u>####</u>	SHEET: DD1 2
N B'	Y	DRAWN BY:	AJL			PD1.3

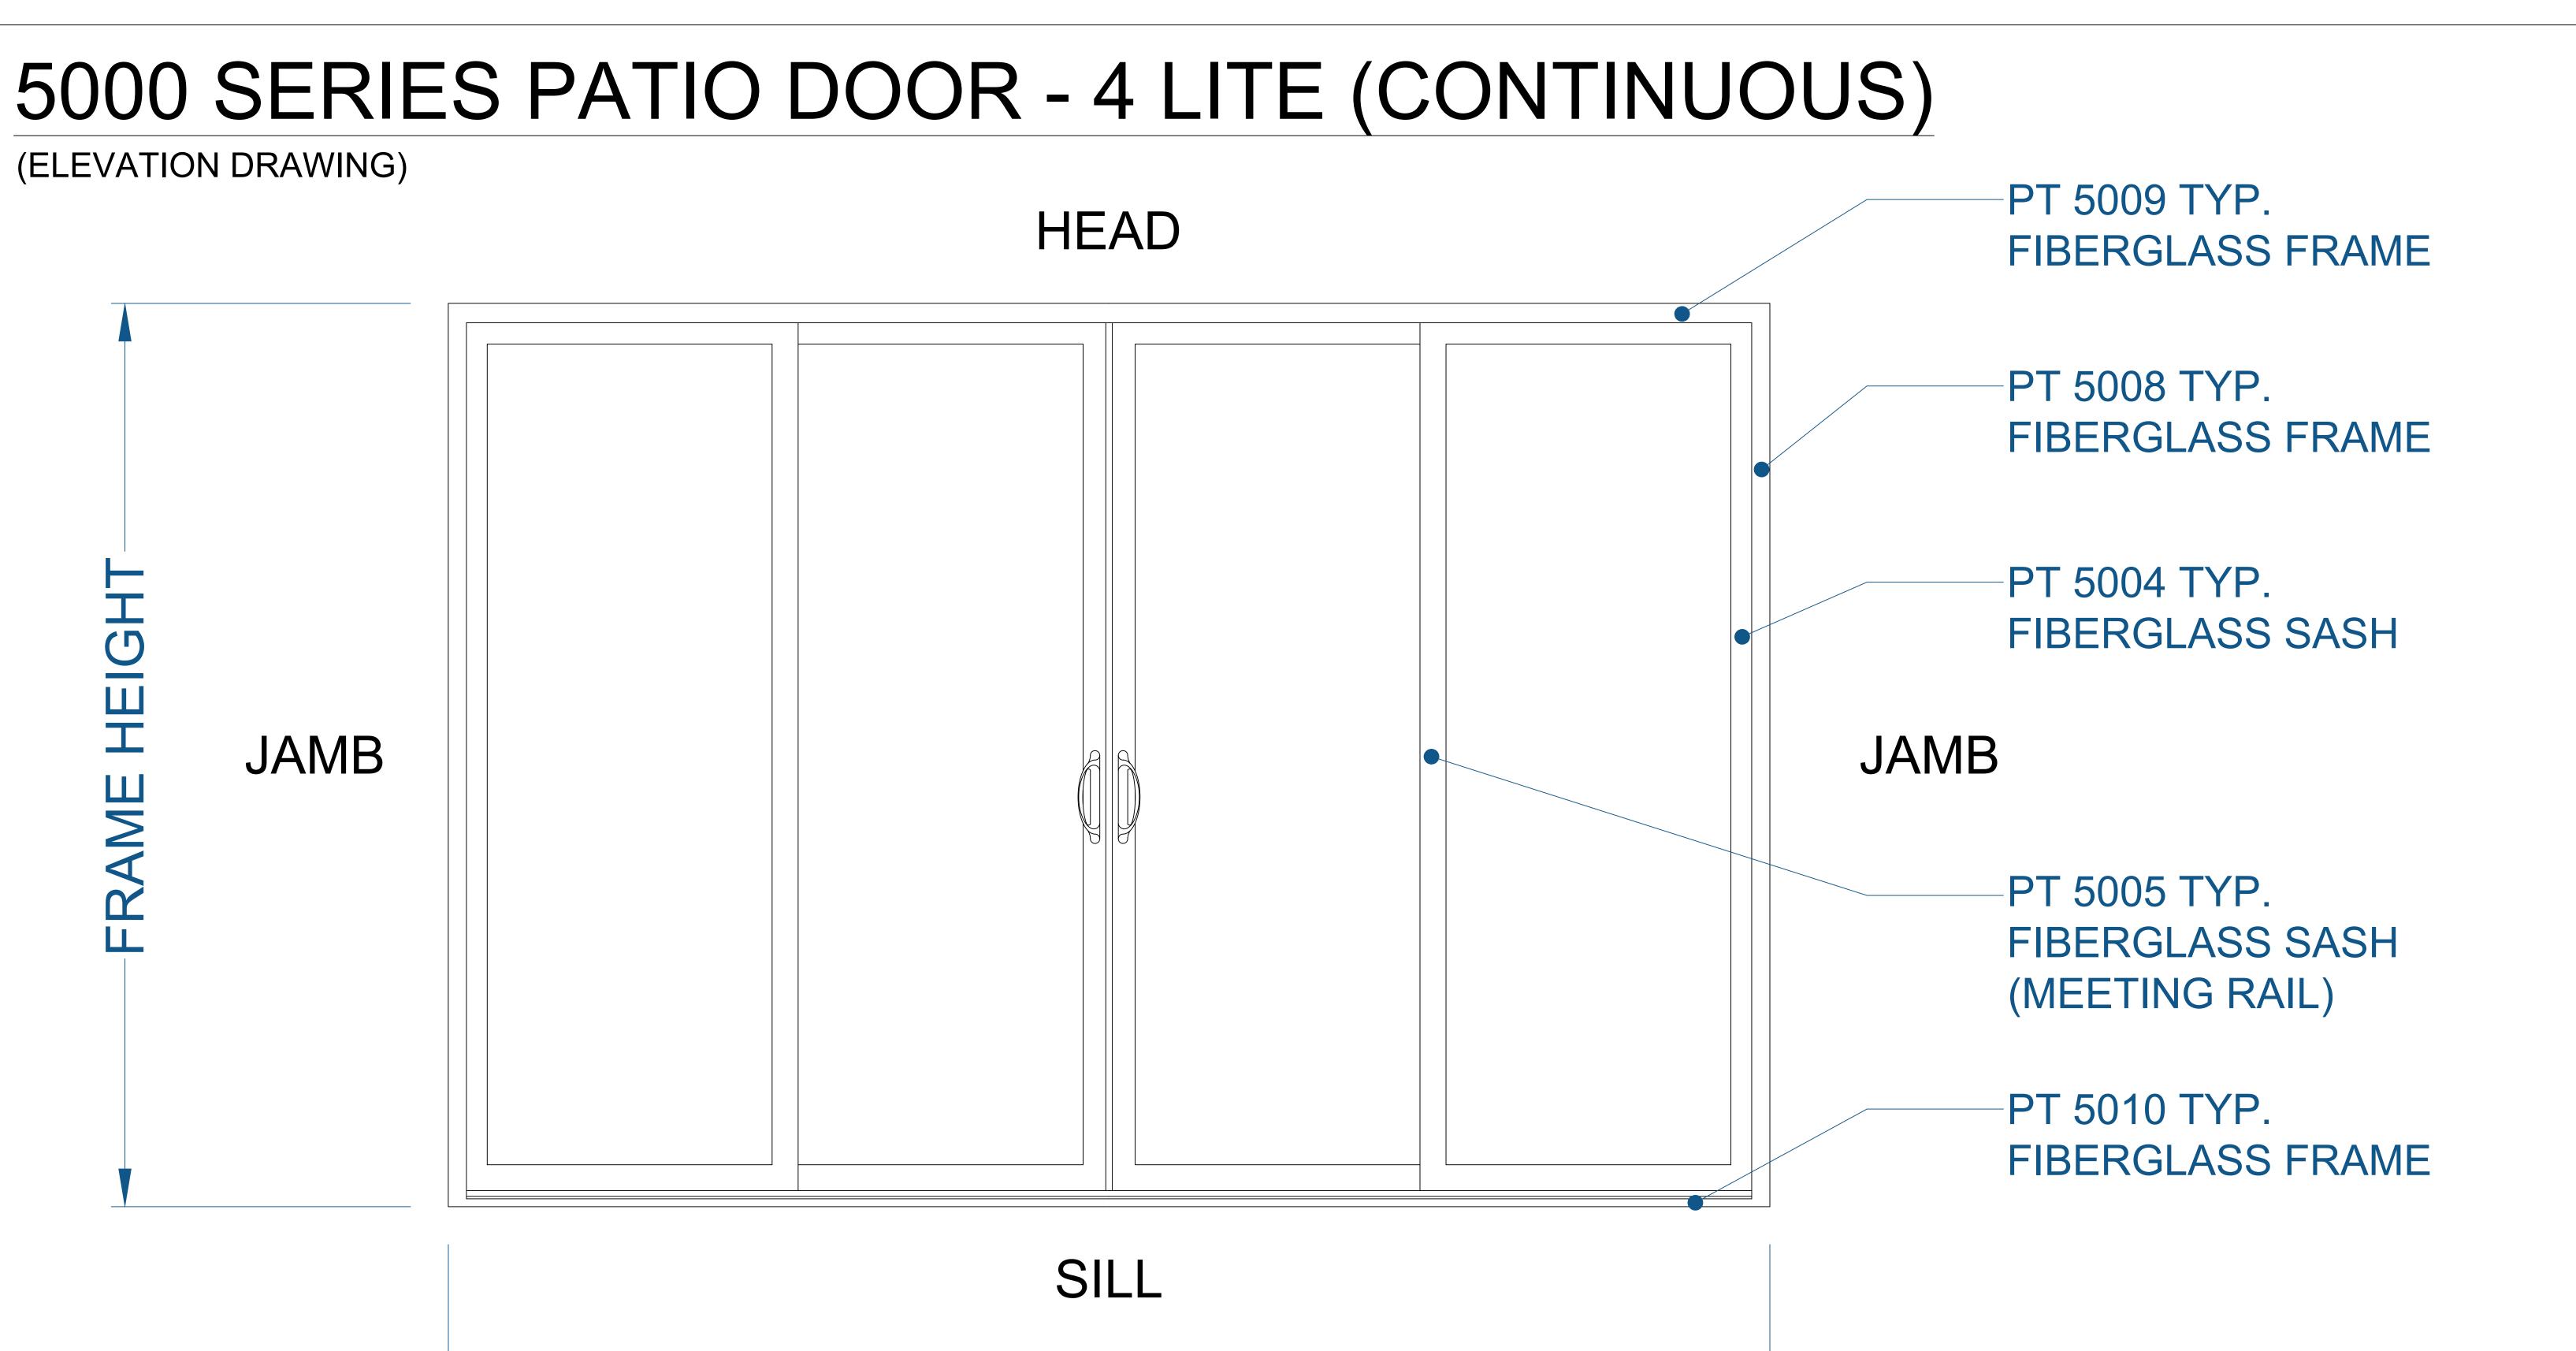


NOTE: ELEVATION VIEWED FROM THE OUTSIDE LOOKING IN.

SEE PRODUCT SPECIFICATIONS PAGE FOR COMPLETE PRODUCT DESCRIPTION.

FRAME WIDTH

SERIE	S/CONFIGURATION	N:			тм	COMFORT	INE LTD.
5000 SERIES PATIO DOOR			Co	berFra		5500 ENTER TOLEDO, OI	RPRISE BLVD. H 43612
DRAWING TYPE:			Fiber	GLASS WINDOWS, PATIO DOORS, SI	UNROOMS & STOREFRONT	419-729-852	
	ELEVATION DRAWING		THIS DRAWING IS THE PROPERTY OF COMFORT LINE LTD.				
			DESIGN CONCEPTS AND INFORMATION MAY NOT BE				
			REPRODUCED USED OR DISCLOSED WITHOUT THE WRITTEN				
			PERMISSION OF COMFORT LINE LTD.				
					PROJECT:		
			SCALE:	6" = 1' - 0"		5000 PAT	
			DATE:	2/13/17	QUOTE:	####	SHEET: DD1 4
DATE	REVISION	BY	DRAWN BY:	AJL		mmm	PD1.4

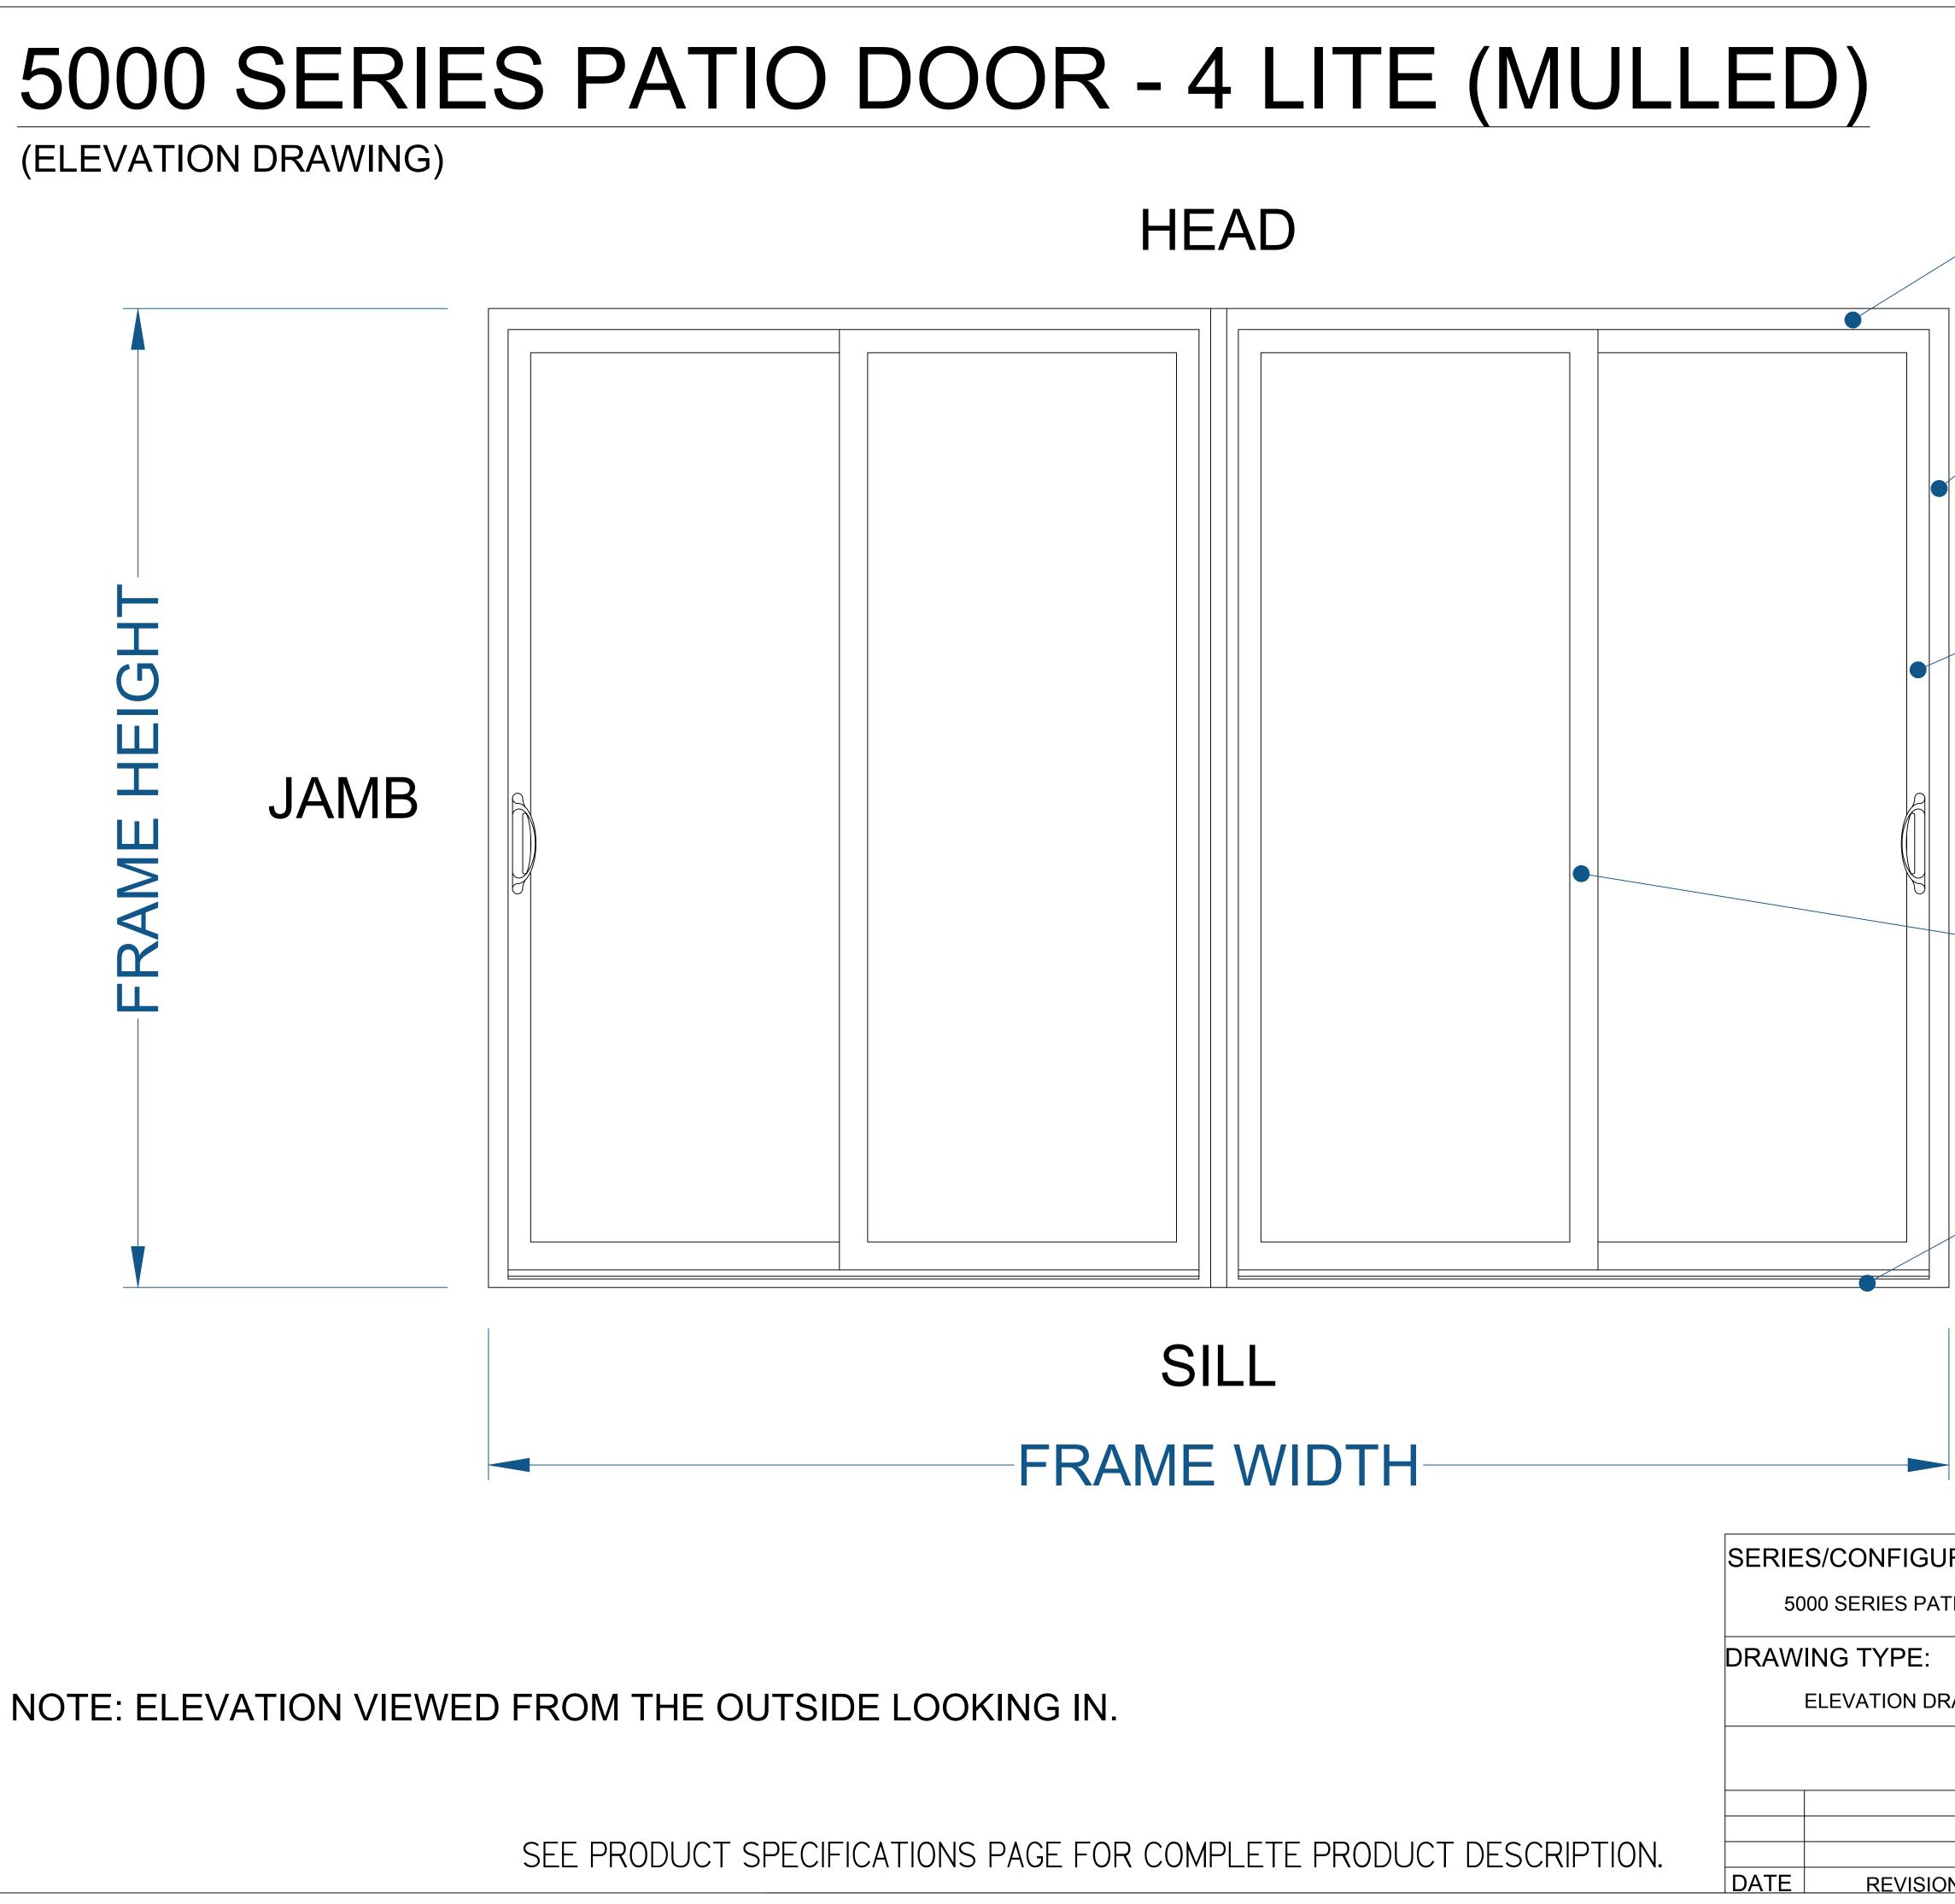

-PT 5009 TYP. FIBERGLASS FRAME

-PT 5008 TYP. FIBERGLASS FRAME


PT 5004 TYP. FIBERGLASS SASH



PT 5005 TYP. FIBERGLASS SASH (MEETING RAIL)

PT 5010 TYP. FIBERGLASS FRAME

RATION	N:			тм	COMFORT L	INE LTD.	
IO DOOR		FiberFrame Comfort Line®			5500 ENTERPRISE BLVD.		
			LASS WINDOWS, PATIO DOORS, SU	INROOMS & STOREFRONT	TOLEDO, OF	143012	
					419-729-852	0	
AWING		THIS DRAWING IS THE PROPERTY OF COMFORT LINE LTD.					
		DESIGN CONCEPTS AND INFORMATION MAY NOT BE					
		REPRODUCED USED OR DISCLOSED WITHOUT THE WRITTEN					
		PERMISS	ION OF COMFO	RT LINE LTD.			
				PROJECT:			
		SCALE:	6" = 1' - 0"		5000 PAT	IU DUUR	
		DATE:	2/13/17	QUOTE:	####	SHEET: DD1 5	
N	BY	DRAWN BY:	AJL			PD1.5	

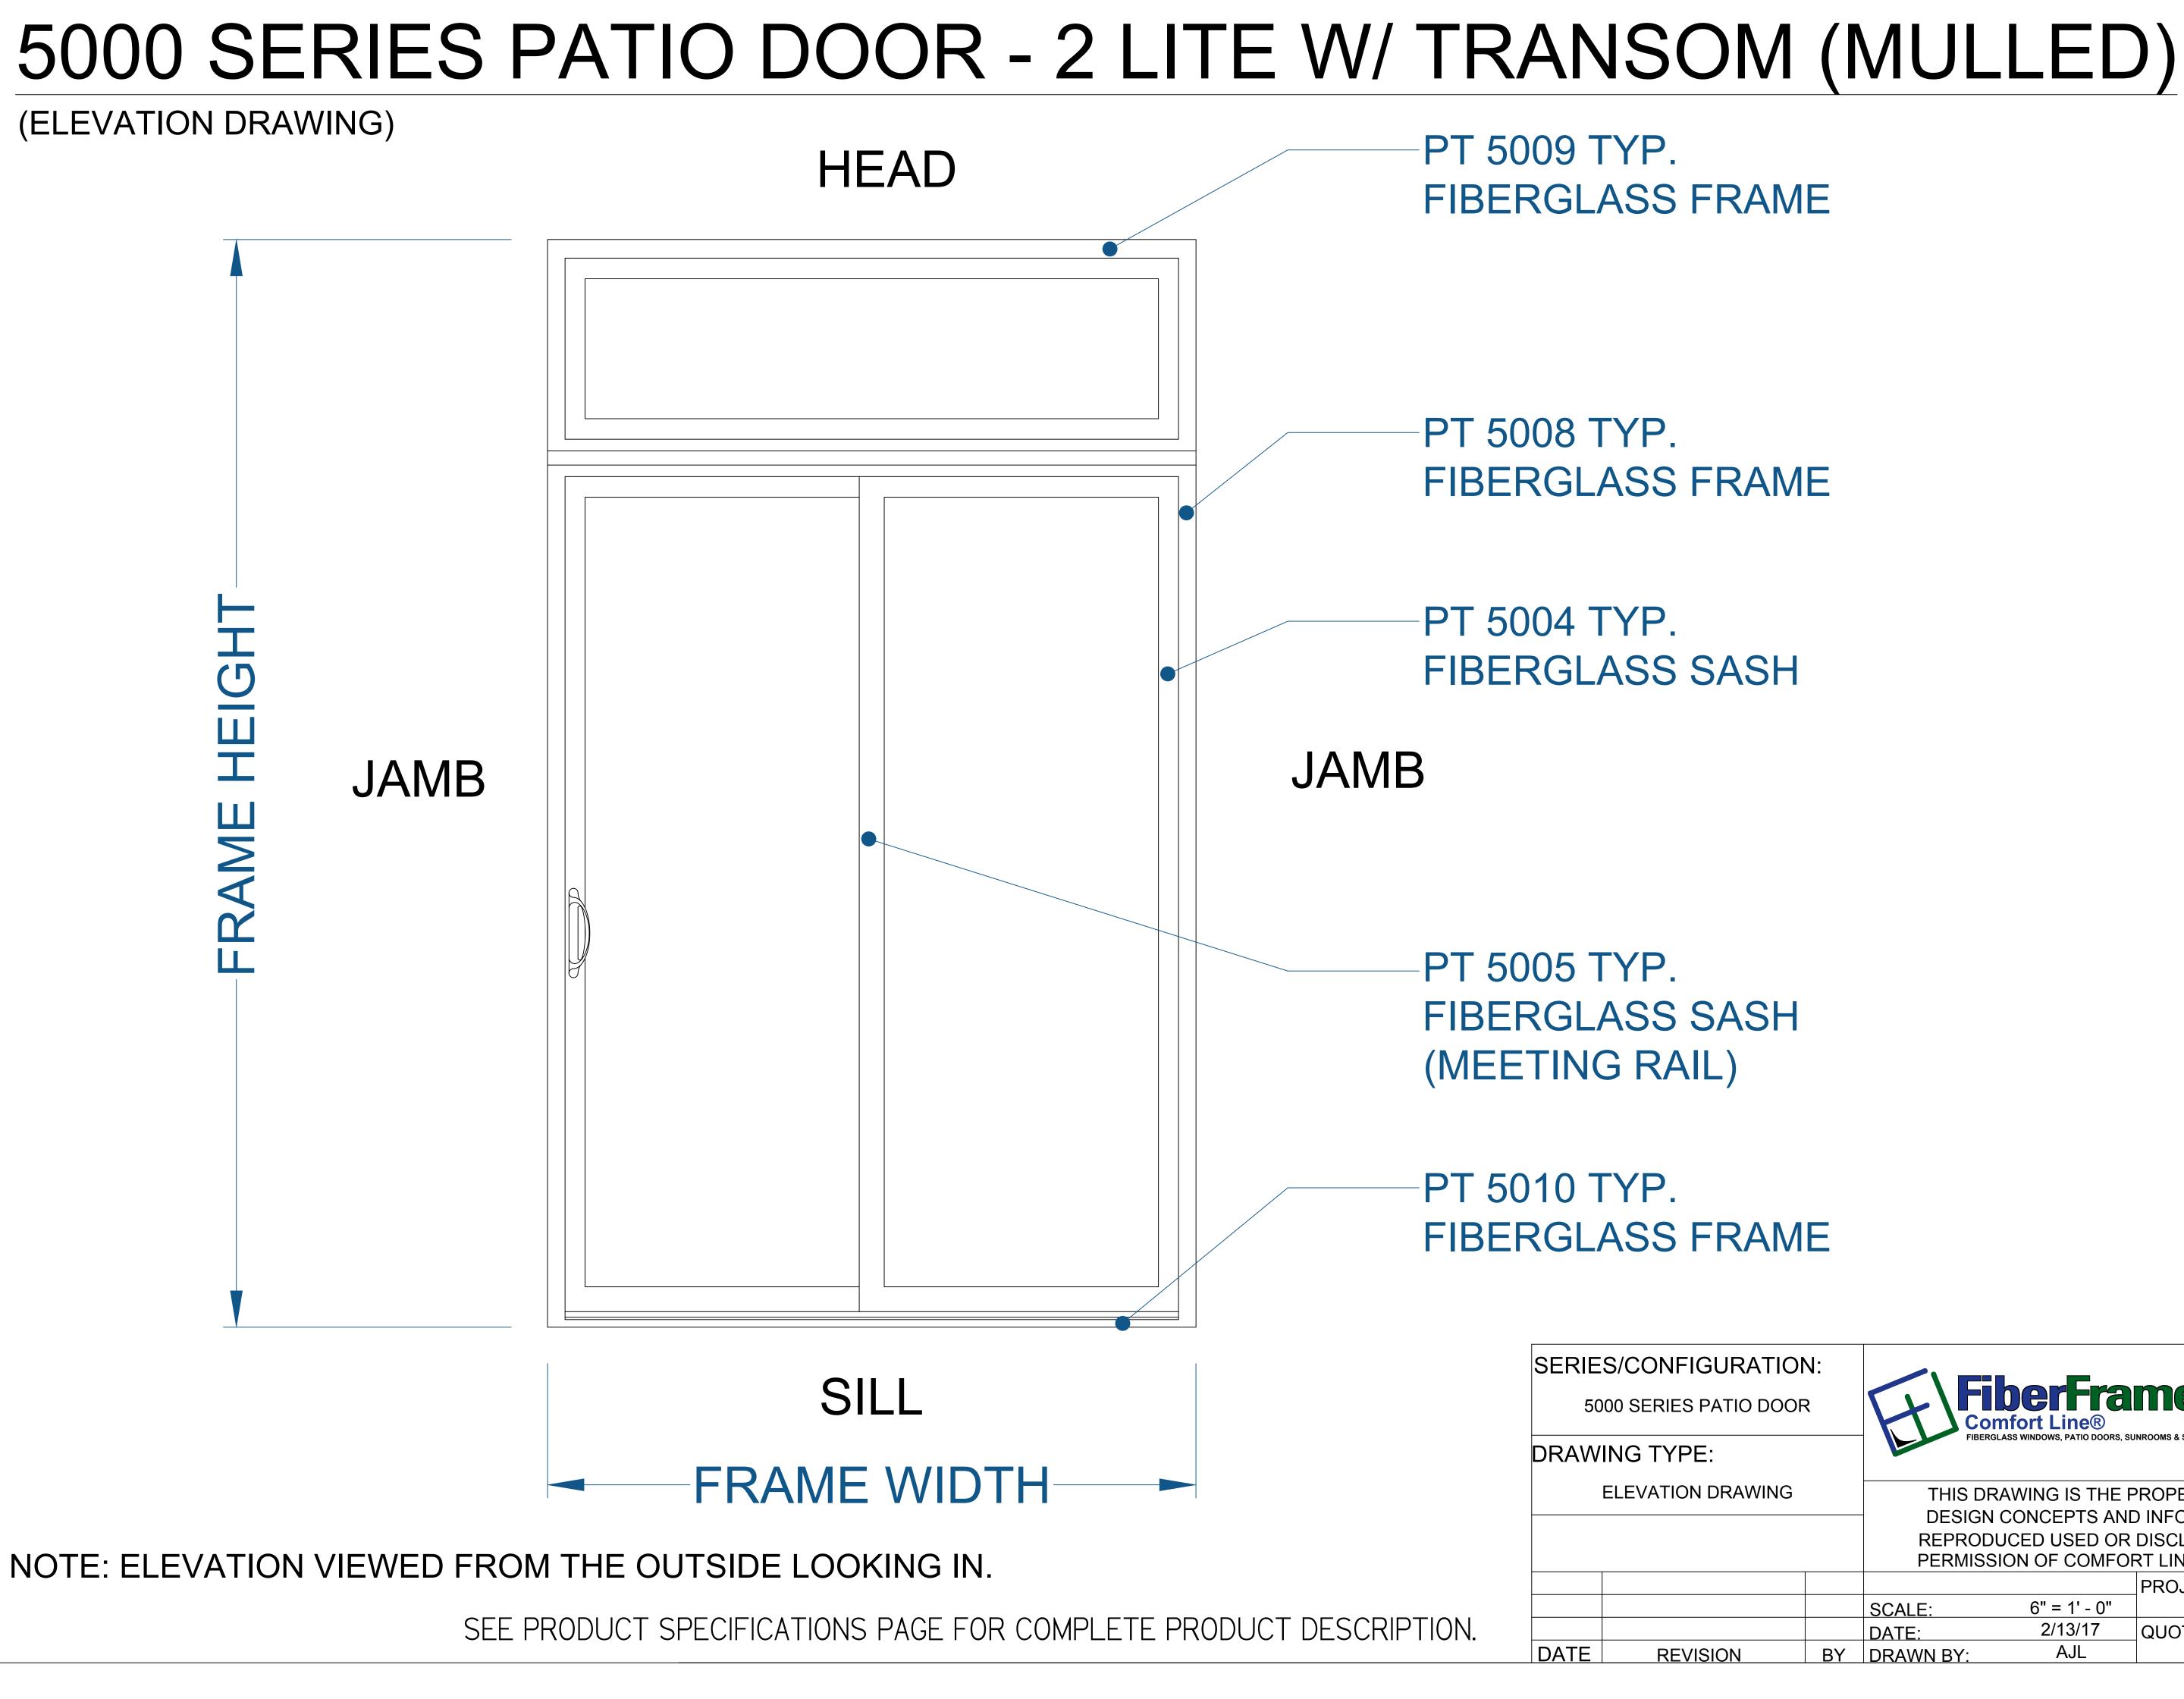

FiberFrame[®] mfort Line® INROOMS & STOREFRONT

COMFORT LINE LTD. 5500 ENTERPRISE BLVD. TOLEDO, OH 43612 419-729-8520


THIS DRAWING IS THE PROPERTY OF COMFORT LINE LTD. DESIGN CONCEPTS AND INFORMATION MAY NOT BE REPRODUCED USED OR DISCLOSED WITHOUT THE WRITTEN PERMISSION OF COMFORT LINE LTD. PROJECT: 5000 PATIO DOOR

SCALE: DATE: BY DRAWN BY: 6" = 1' - 0" 2/13/17 AJL

QUOTE:


####

SHEET: PD1.6

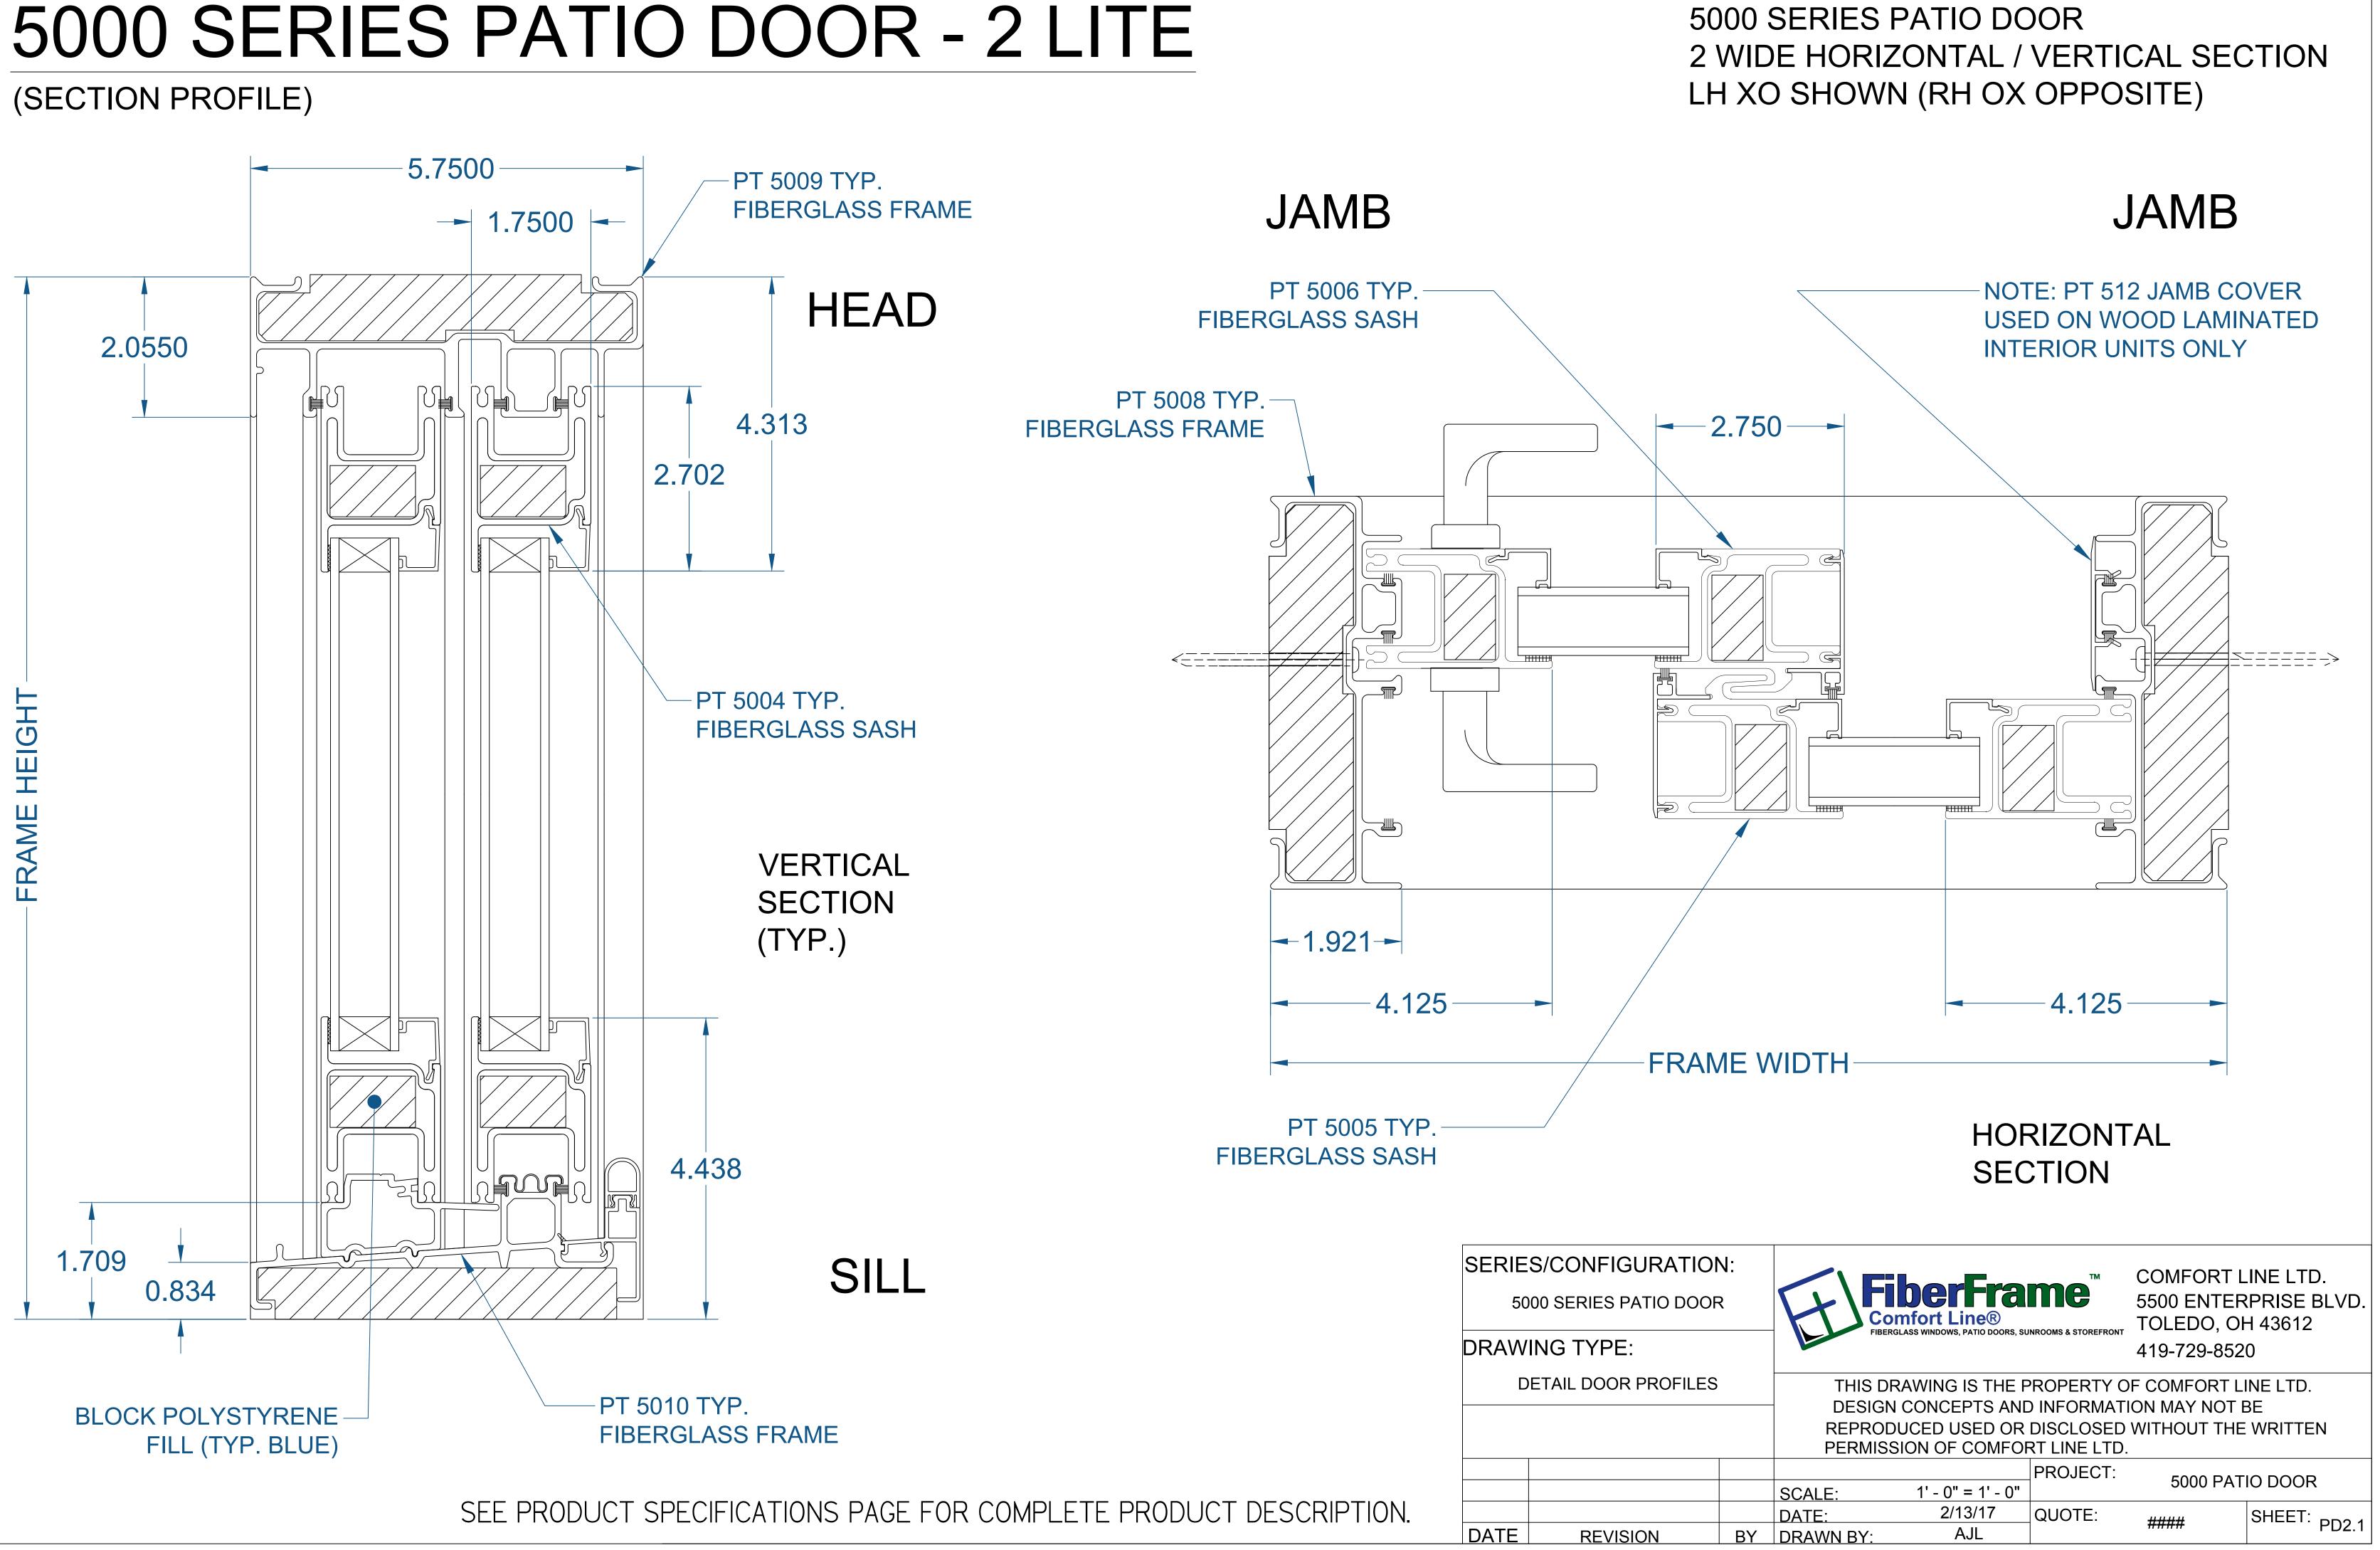


5000 SERIES PATIO DOOR




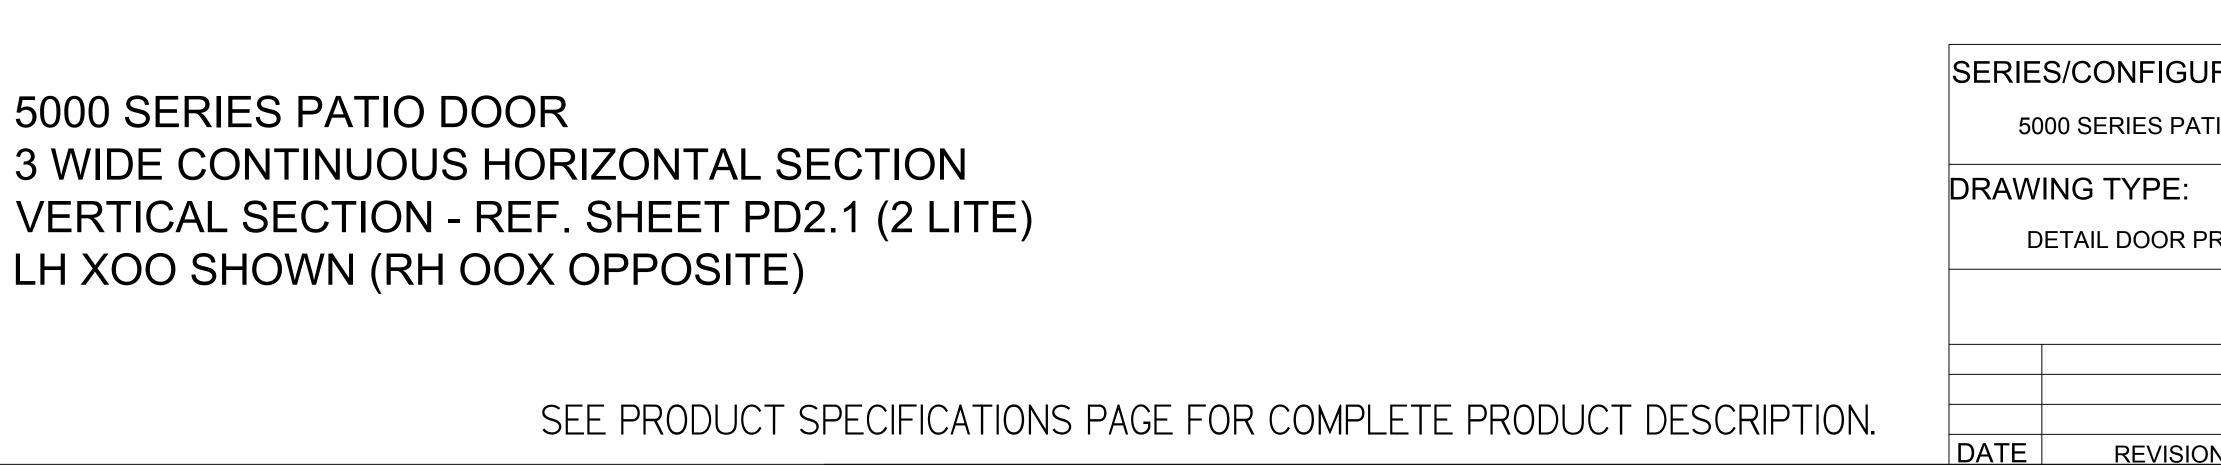



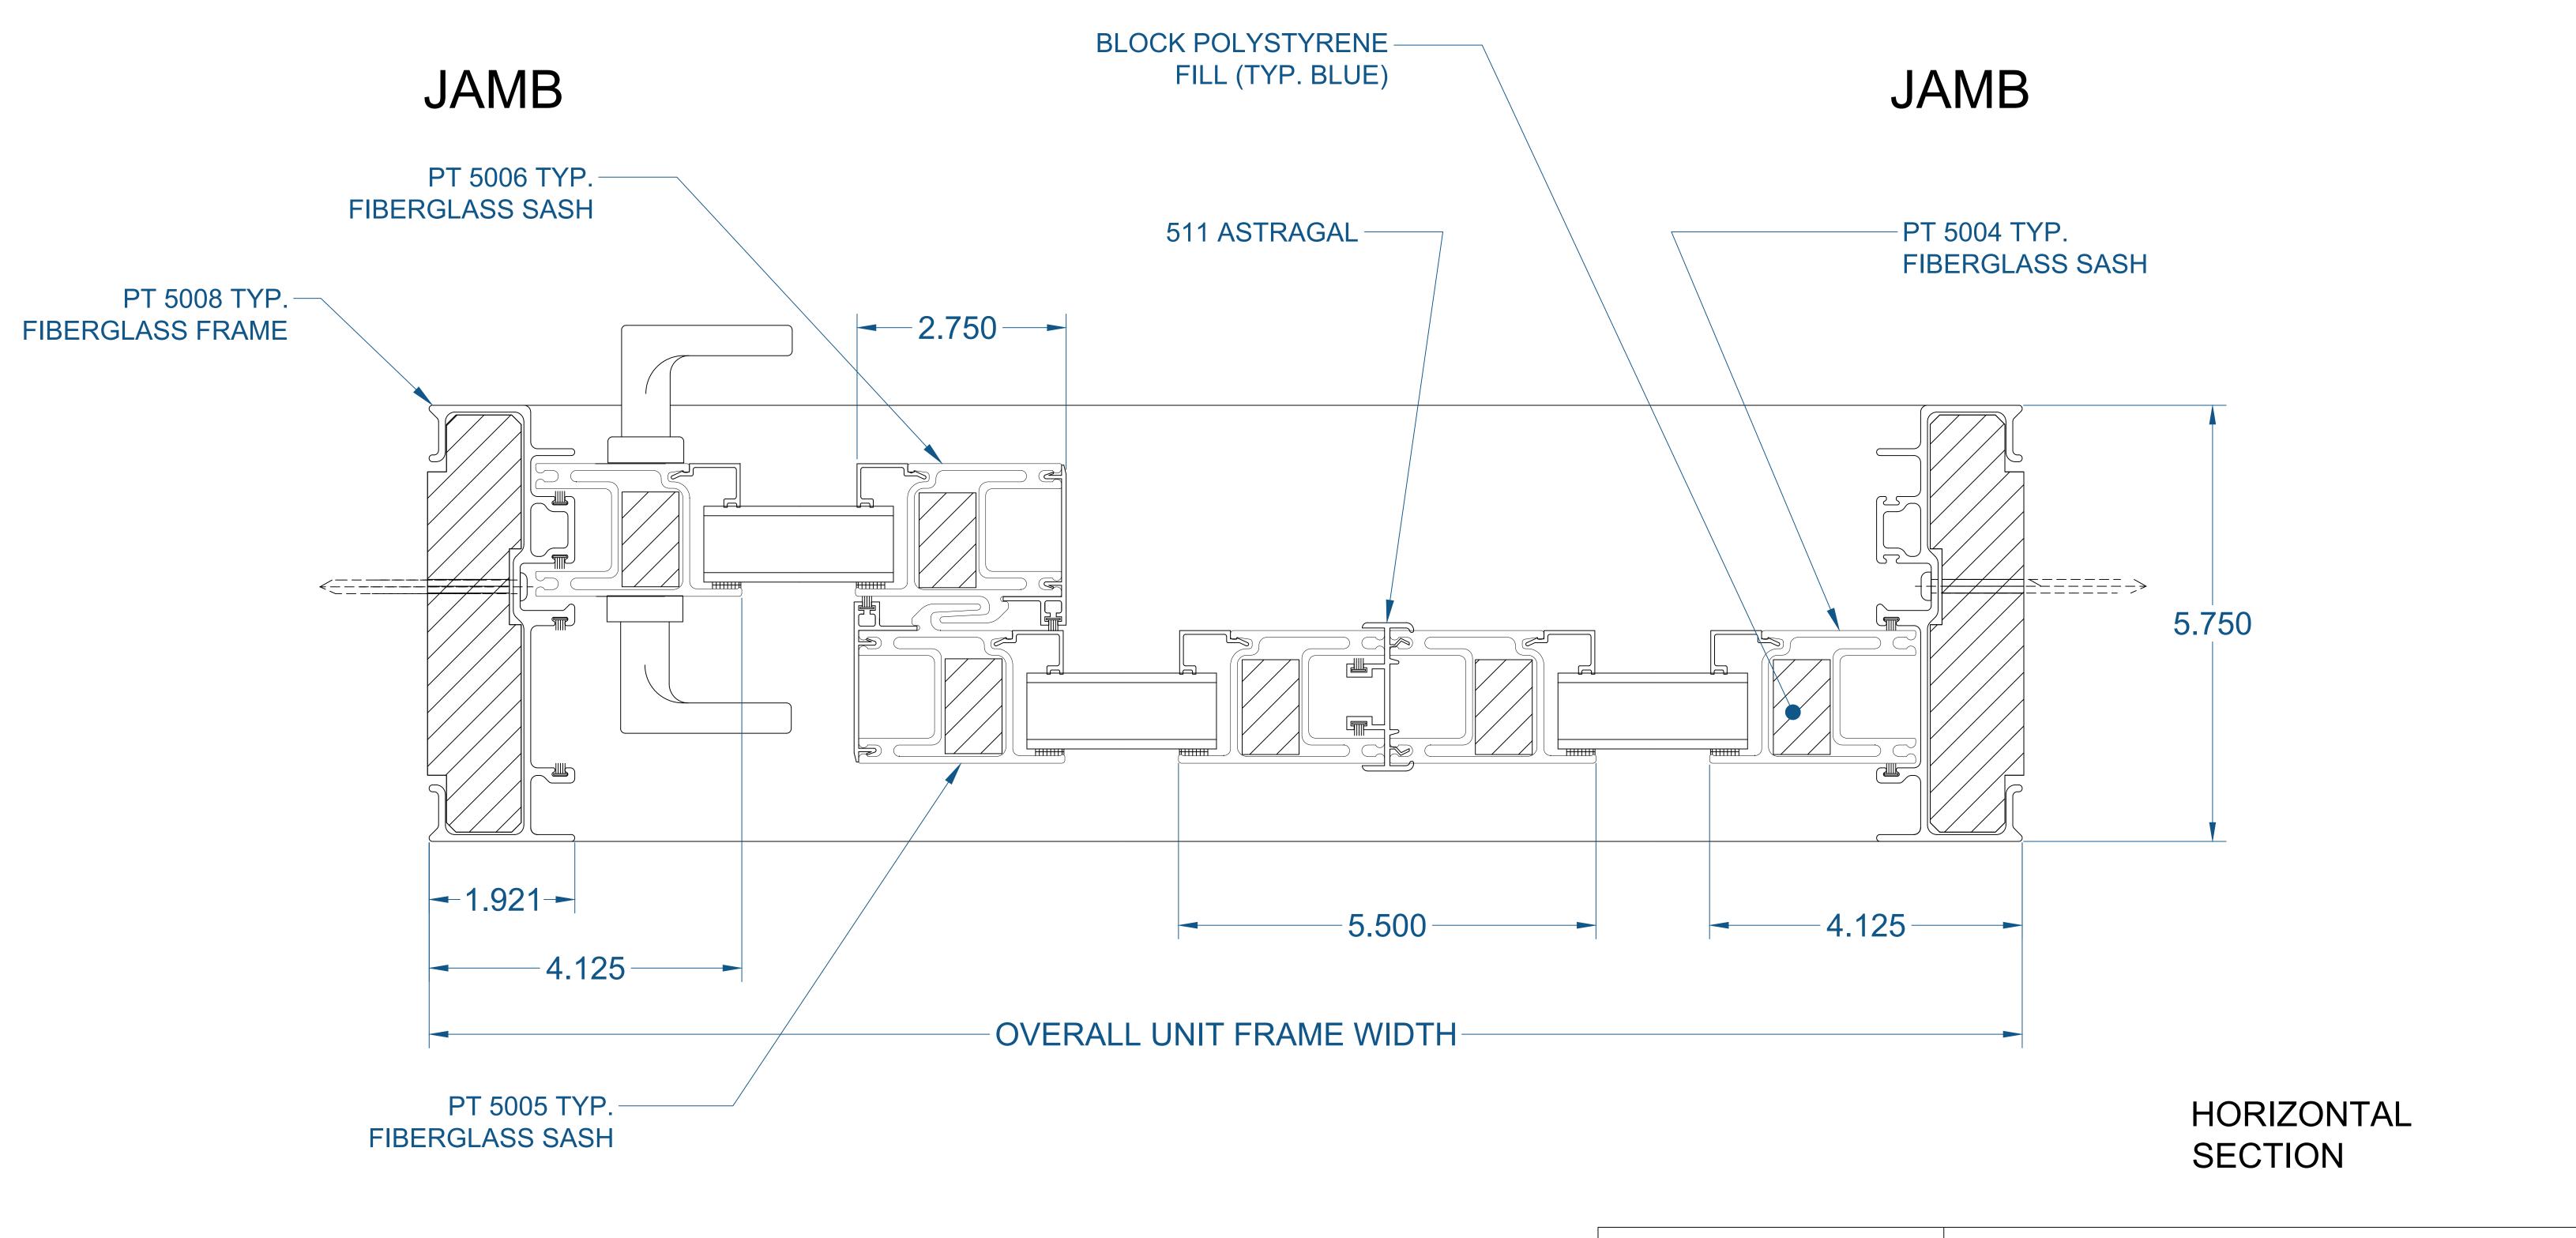

5000 SERIES PATIO DOOR - 3 LITE (CONTINUOUS) (SECTION PROFILE)

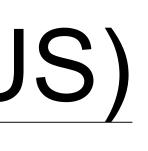




RATION	N:		_	тм	COMFORT L	INE LTD.	
FIO DOOF	R		berFra	me	5500 ENTERPRISE BLVD.		
		FiBERG	LASS WINDOWS, PATIO DOORS, SU	INROOMS & STOREFRONT	TOLEDO, OH 43612 419-729-8520		
ROFILES		THIS DR	AWING IS THE F	ROPERTY O	F COMFORT L	INE LTD.	
		DESIGN CONCEPTS AND INFORMATION MAY NOT BE					
		_	UCED USED OR		WITHOUT THE	WRITTEN	
				PROJECT:			
		SCALE:	1' - 0" = 1' - 0"		5000 PAT	IO DOOR	
		DATE:	2/13/17	QUOTE:	####	SHEET: DDa a	
N	BY	DRAWN BY:	AJL			PD2.2	

5000 SERIES PATIO DOOR - 3 LITE (MULLED) (SECTION PROFILE)


PT 5006 TYP. **FIBERGLASS SASH**

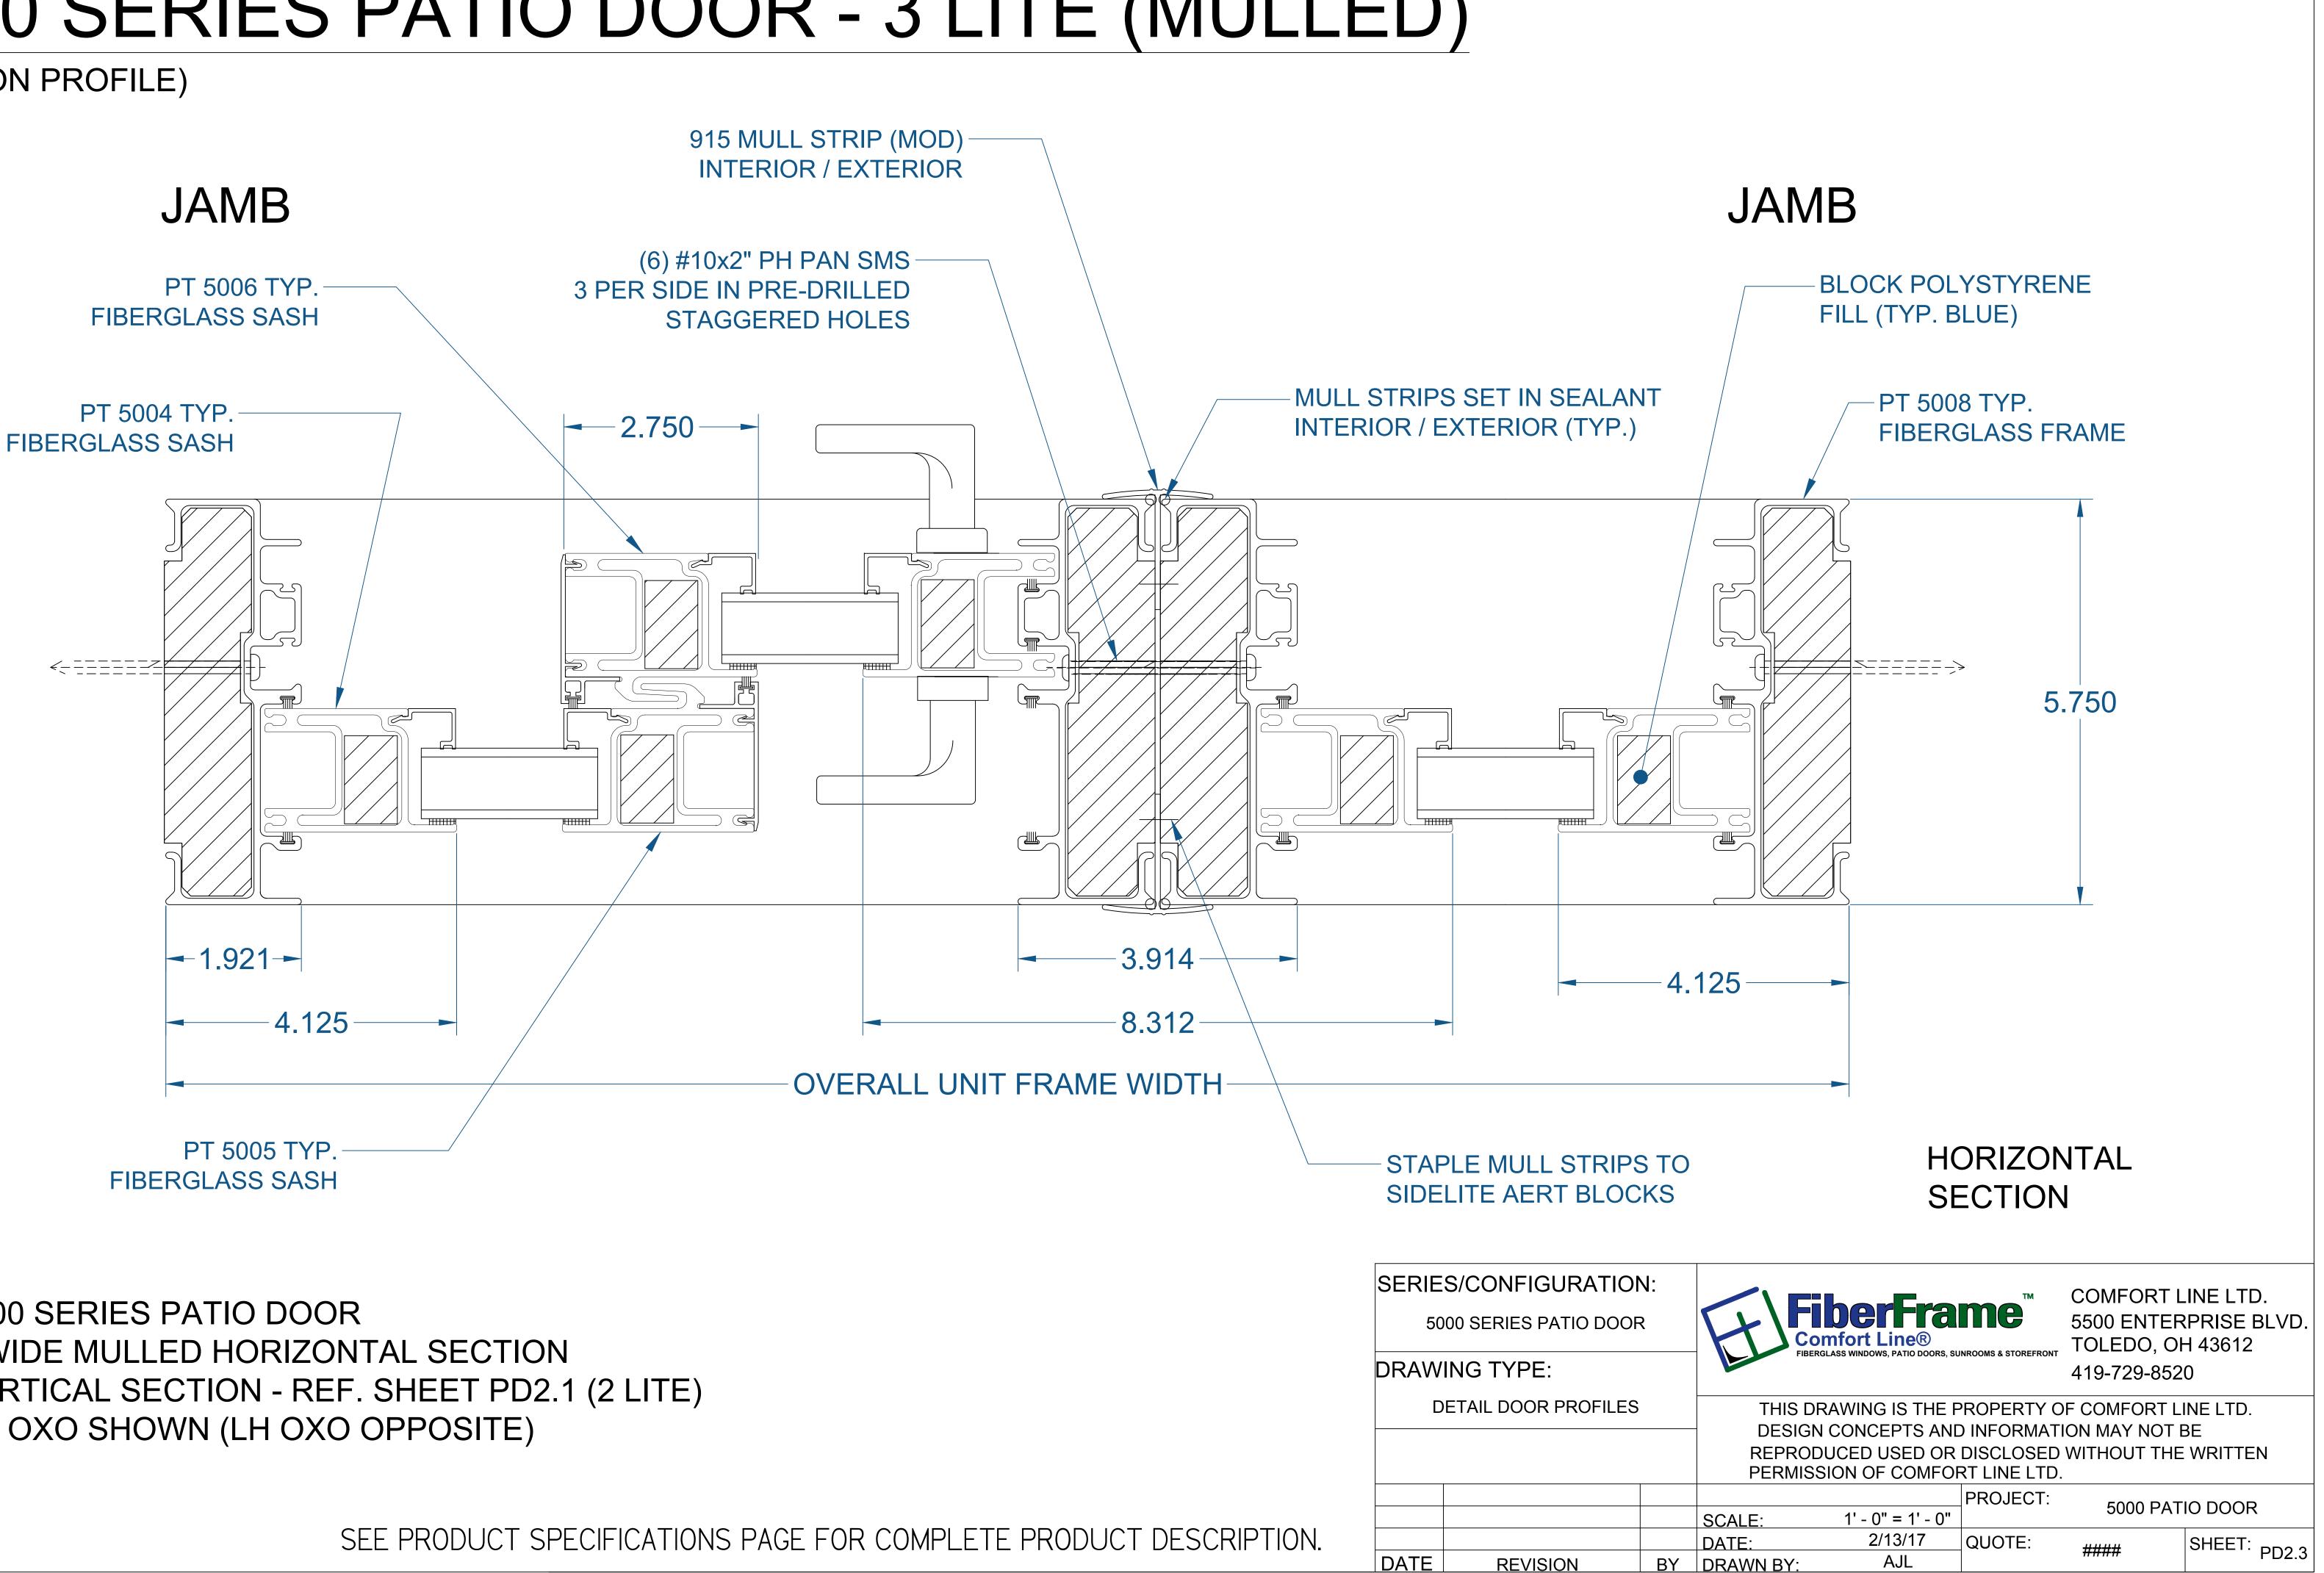


5000 SERIES PATIO DOOR **3 WIDE MULLED HORIZONTAL SECTION** VERTICAL SECTION - REF. SHEET PD2.1 (2 LITE) RH OXO SHOWN (LH OXO OPPOSITE)

5000 SERIES PATIO DOOR - 4 LITE (CONTINUOUS) (SECTION PROFILE)

JAMB

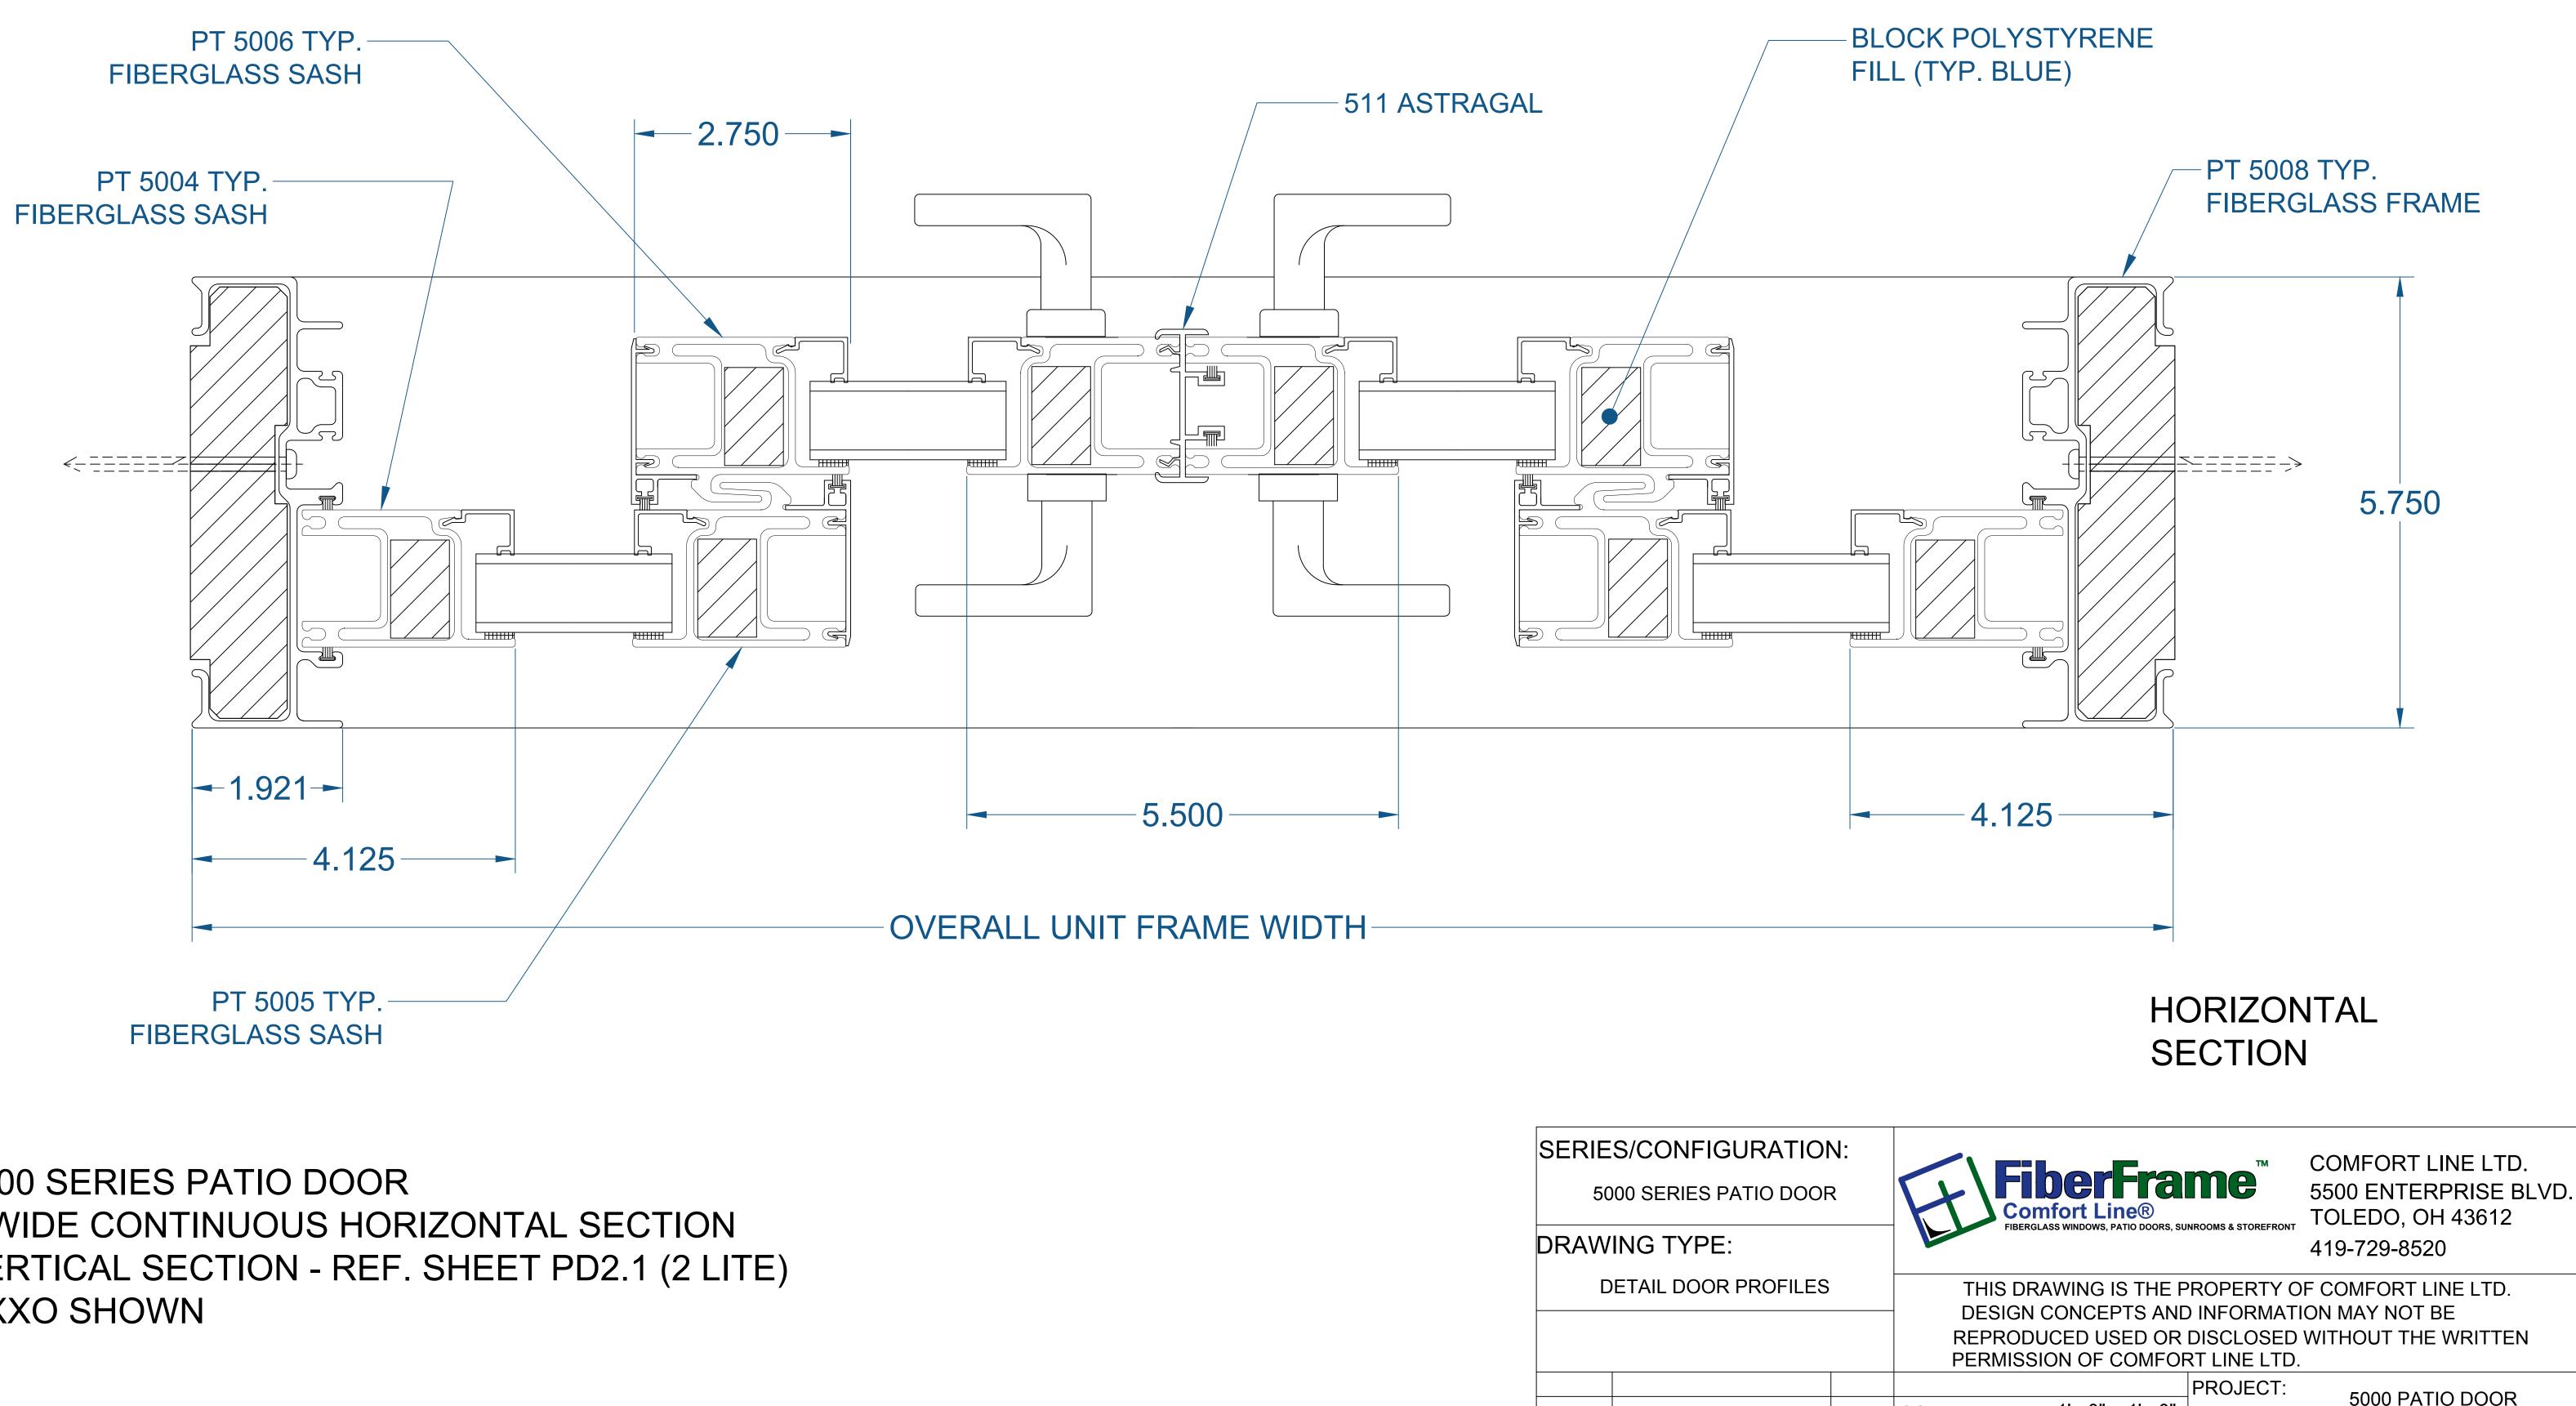


5000 SERIES PATIO DOOR 4 WIDE CONTINUOUS HORIZONTAL SECTION VERTICAL SECTION - REF. SHEET PD2.1 (2 LITE) OXXO SHOWN

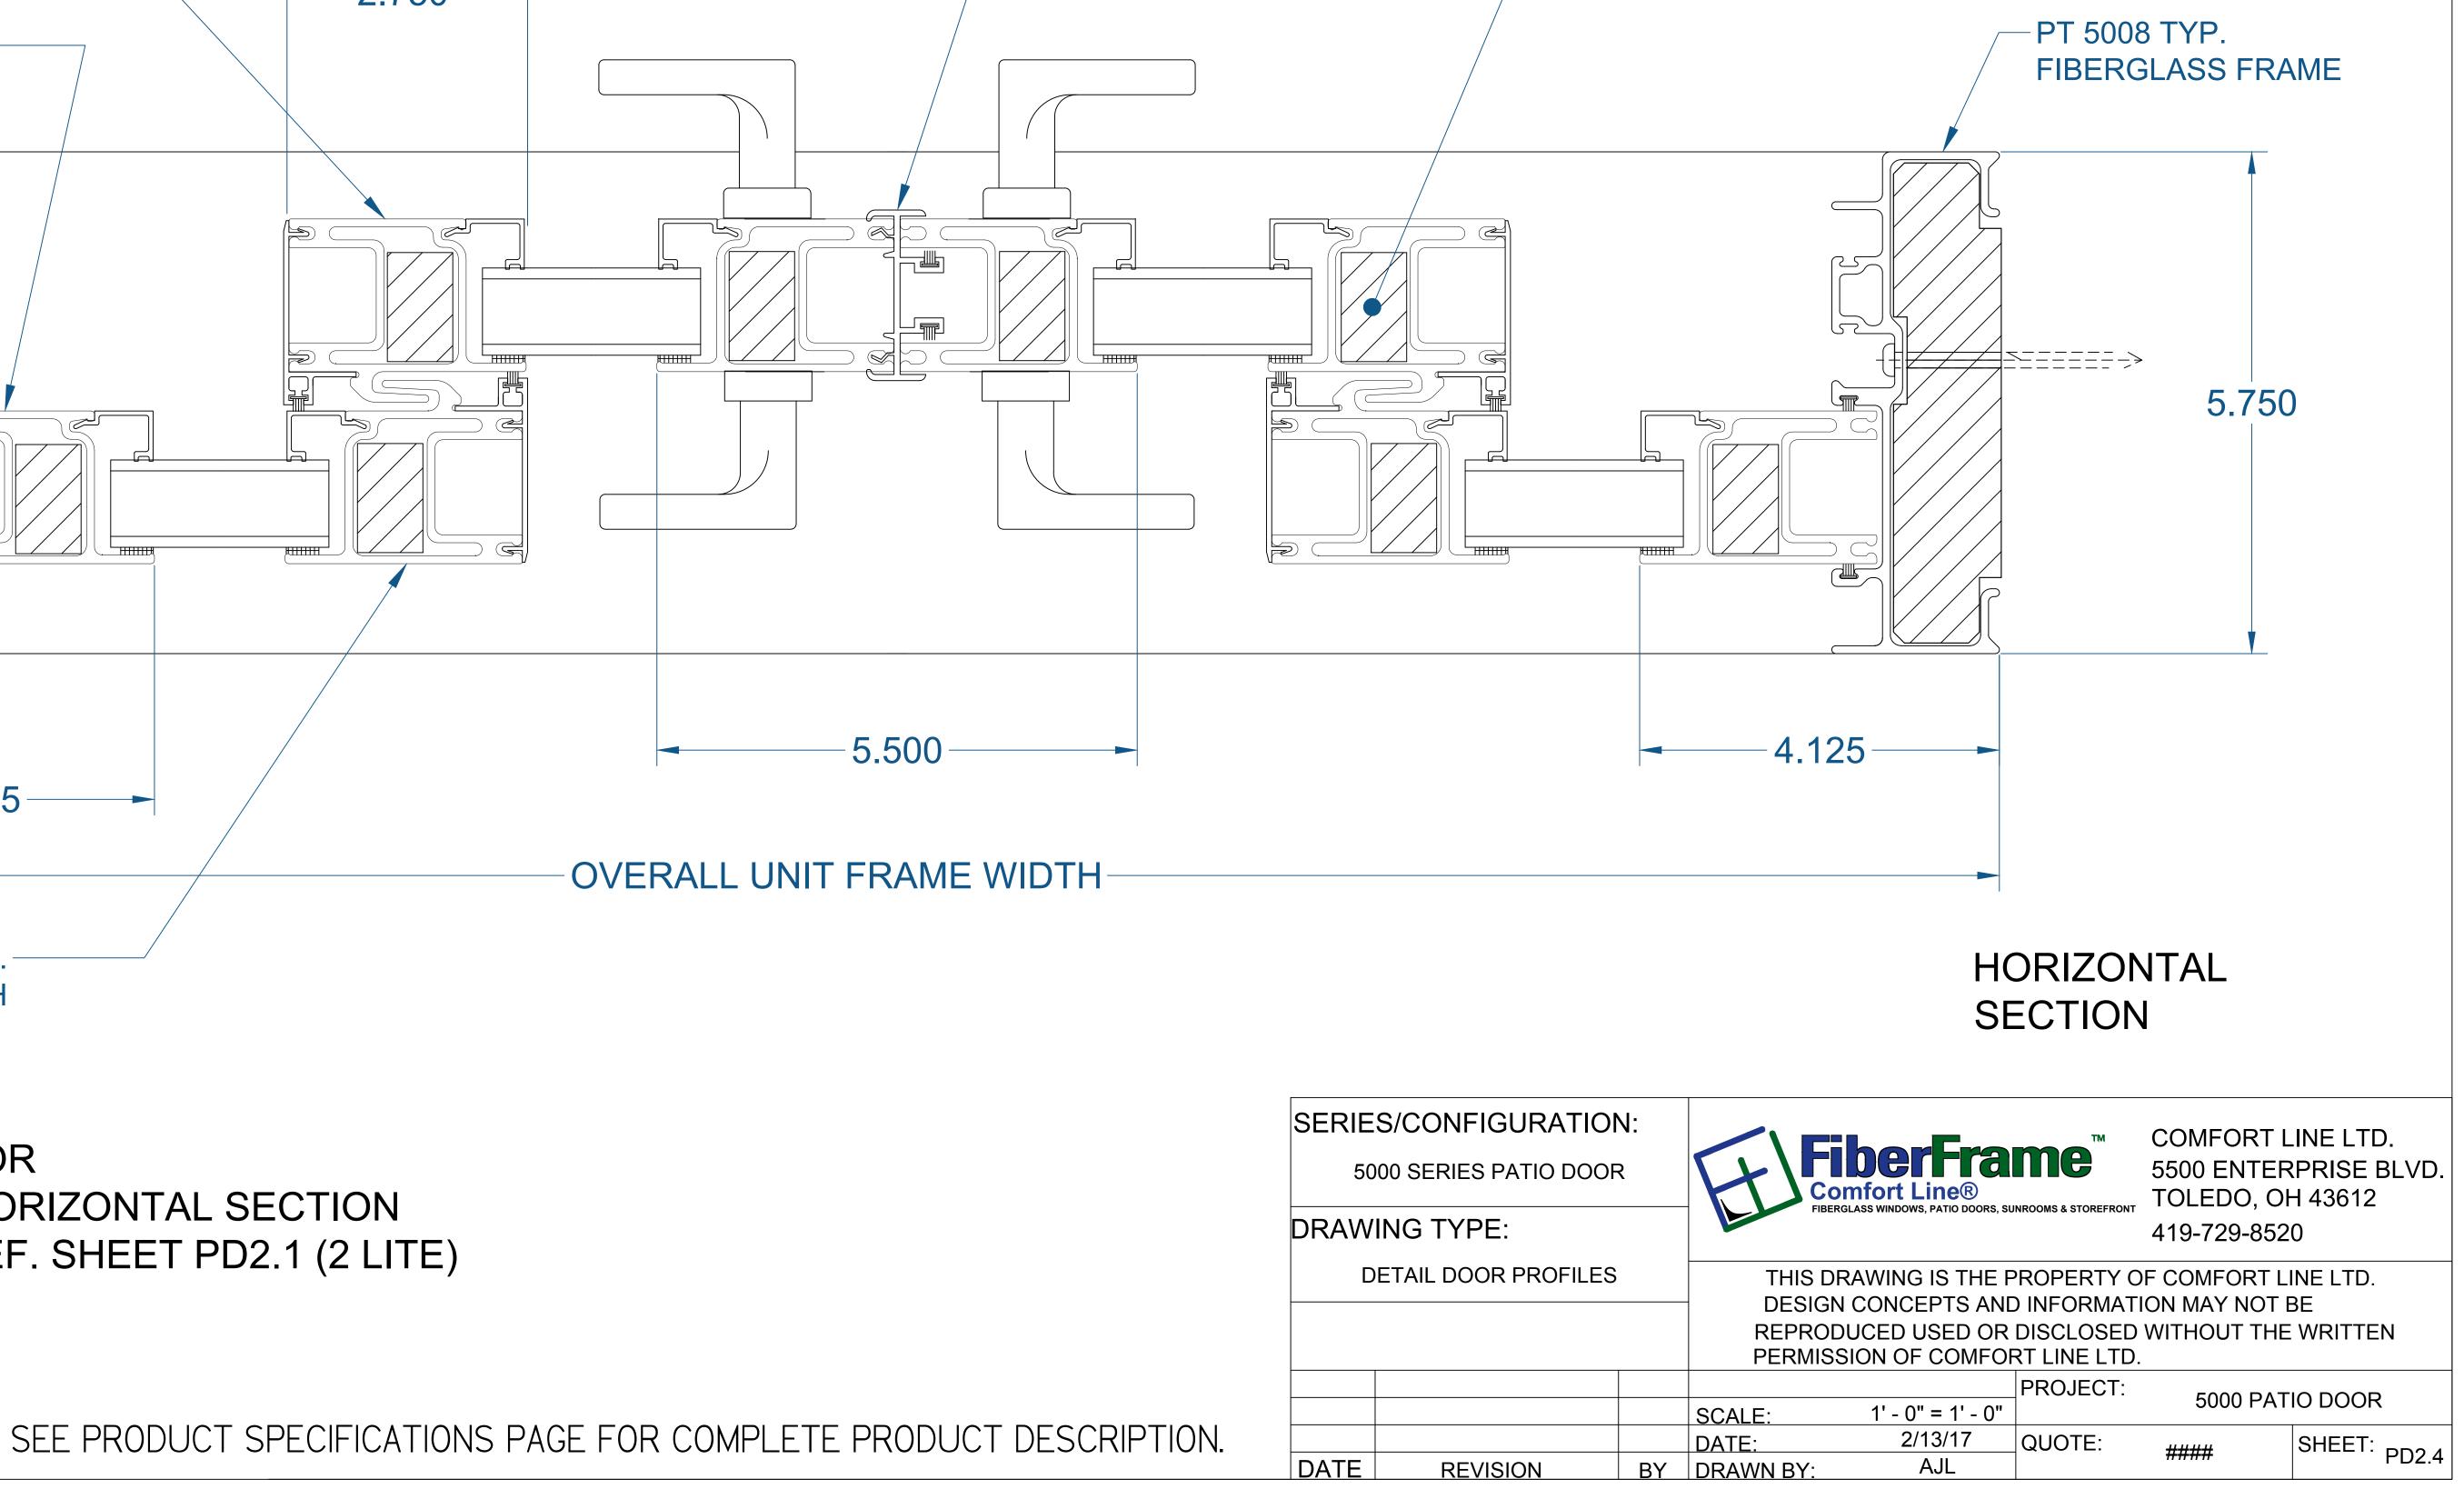

JAMB




5000 SERIES PATIO DOOR - 4 LITE (MULLED) (SECTION PROFILE)

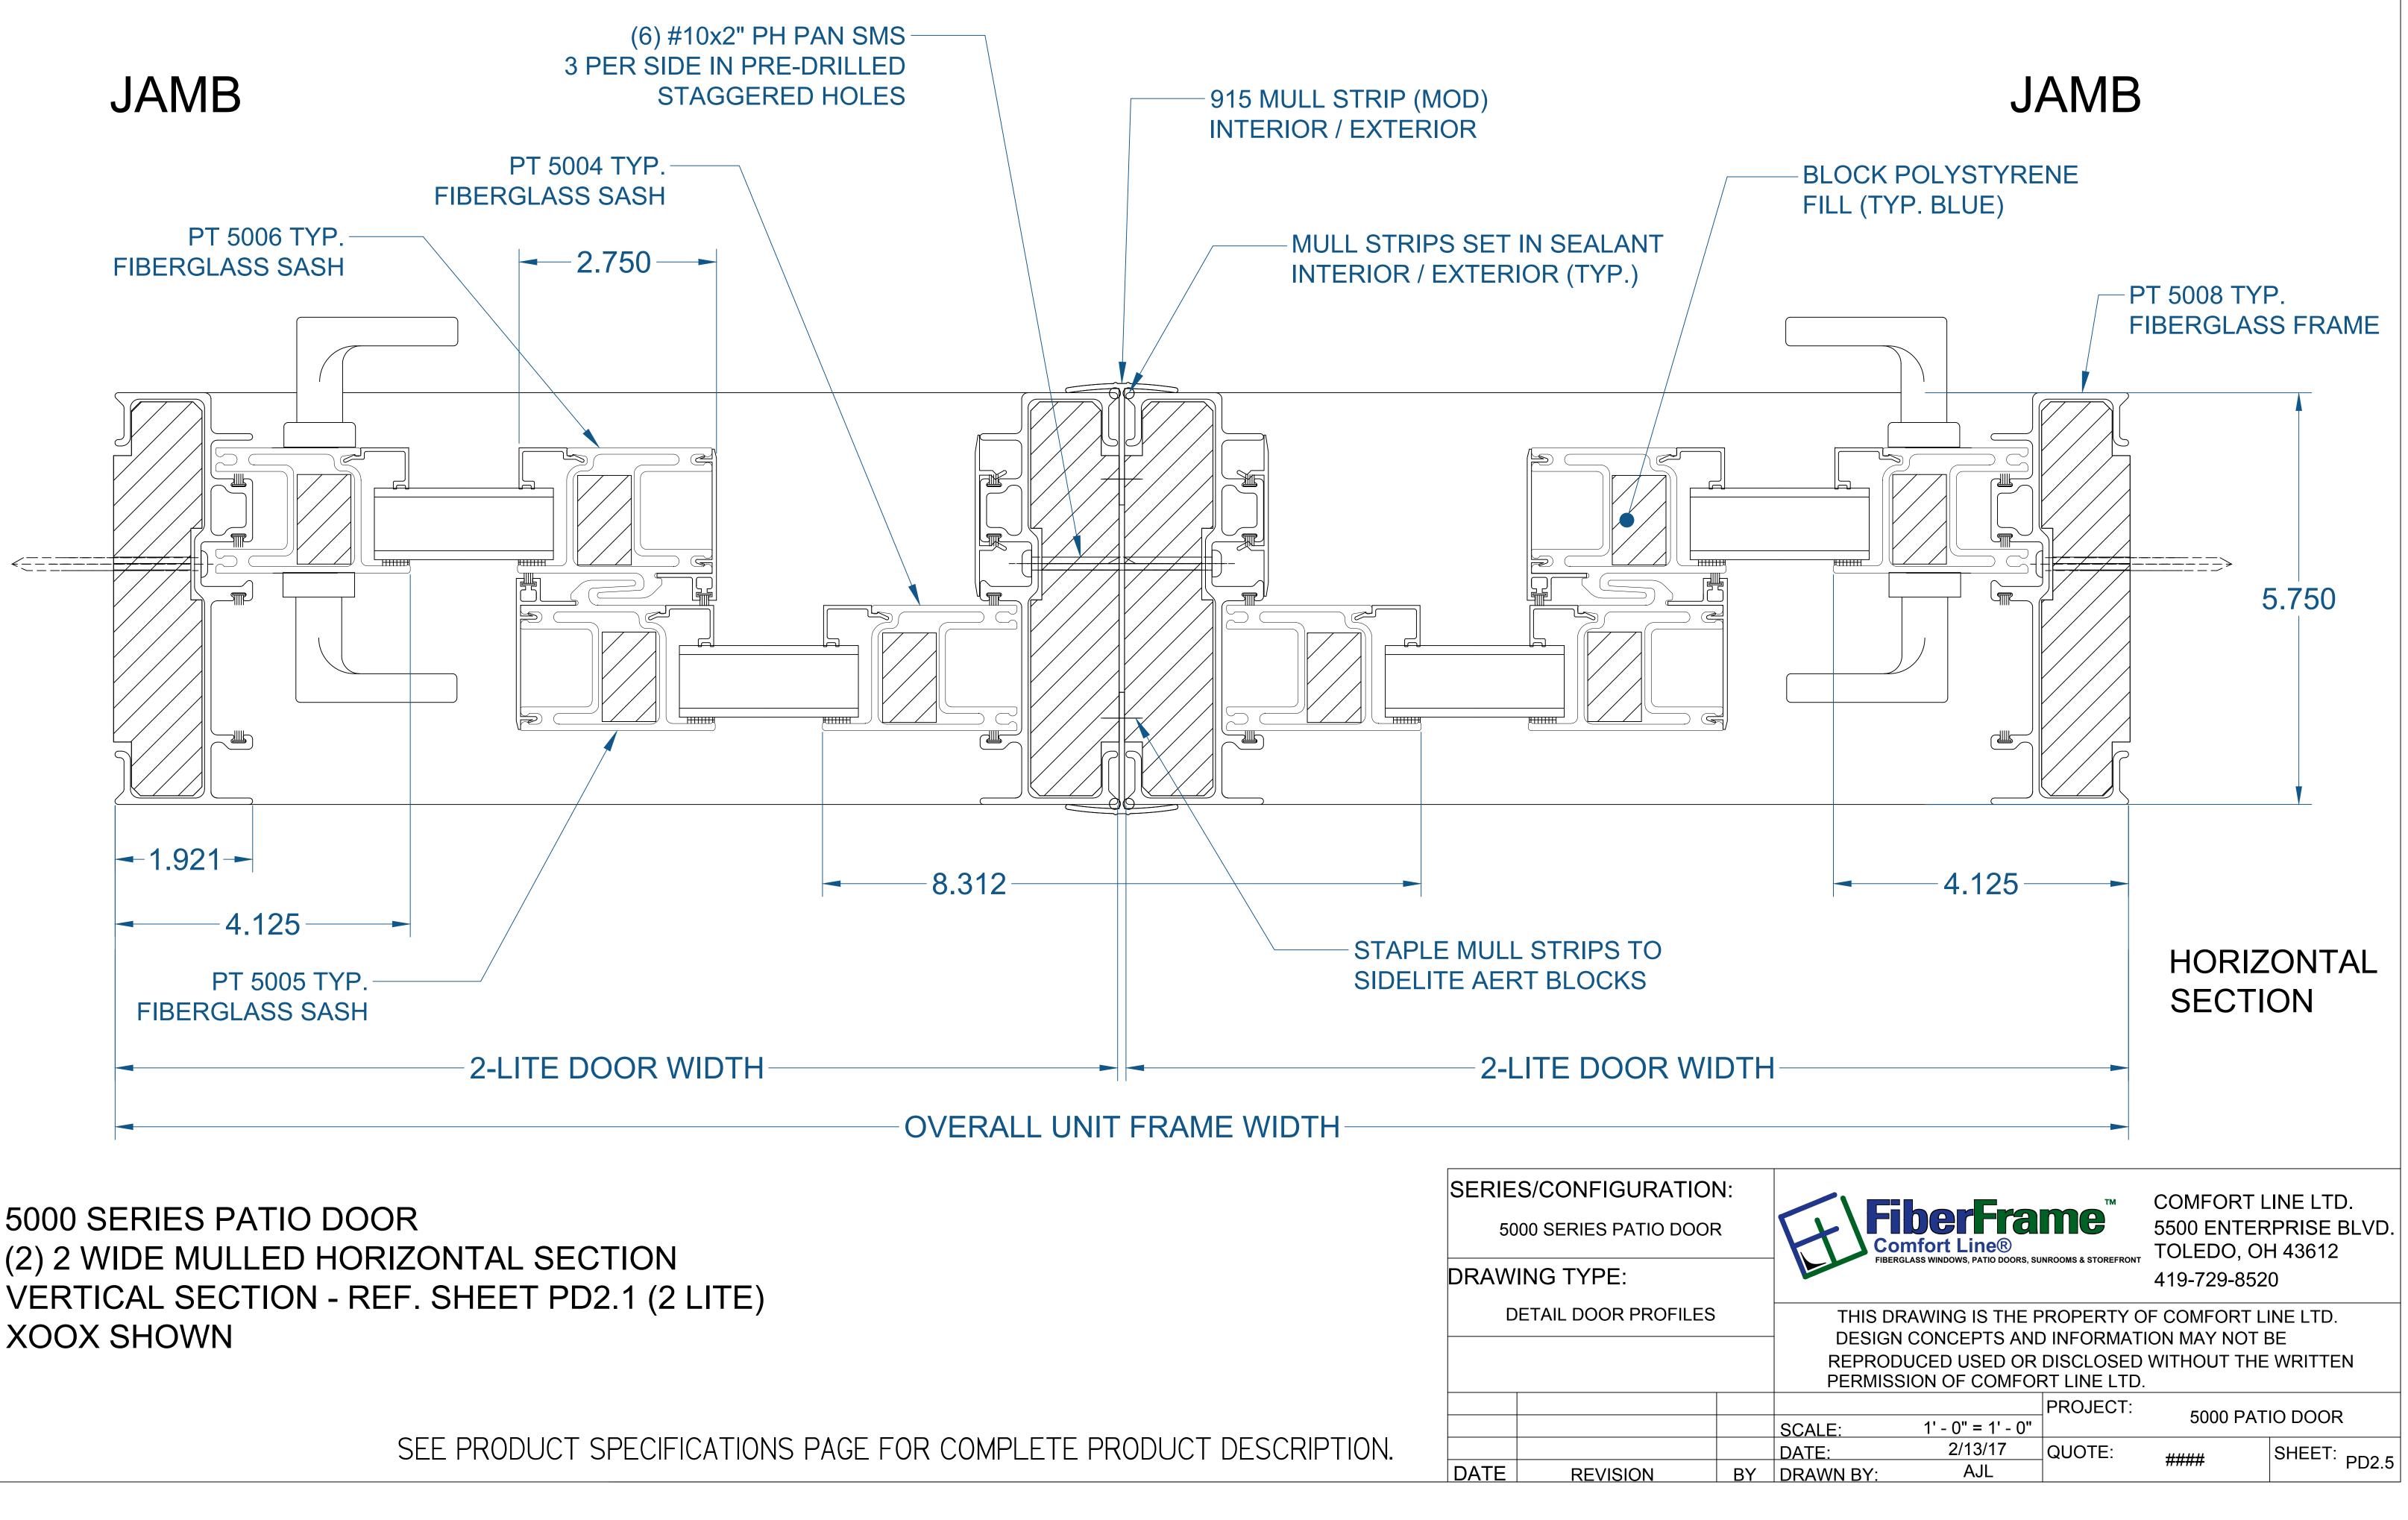

5000 SERIES PATIO DOOR (2) 2 WIDE MULLED HORIZONTAL SECTION XOOX SHOWN

(SECTION PROFILE)

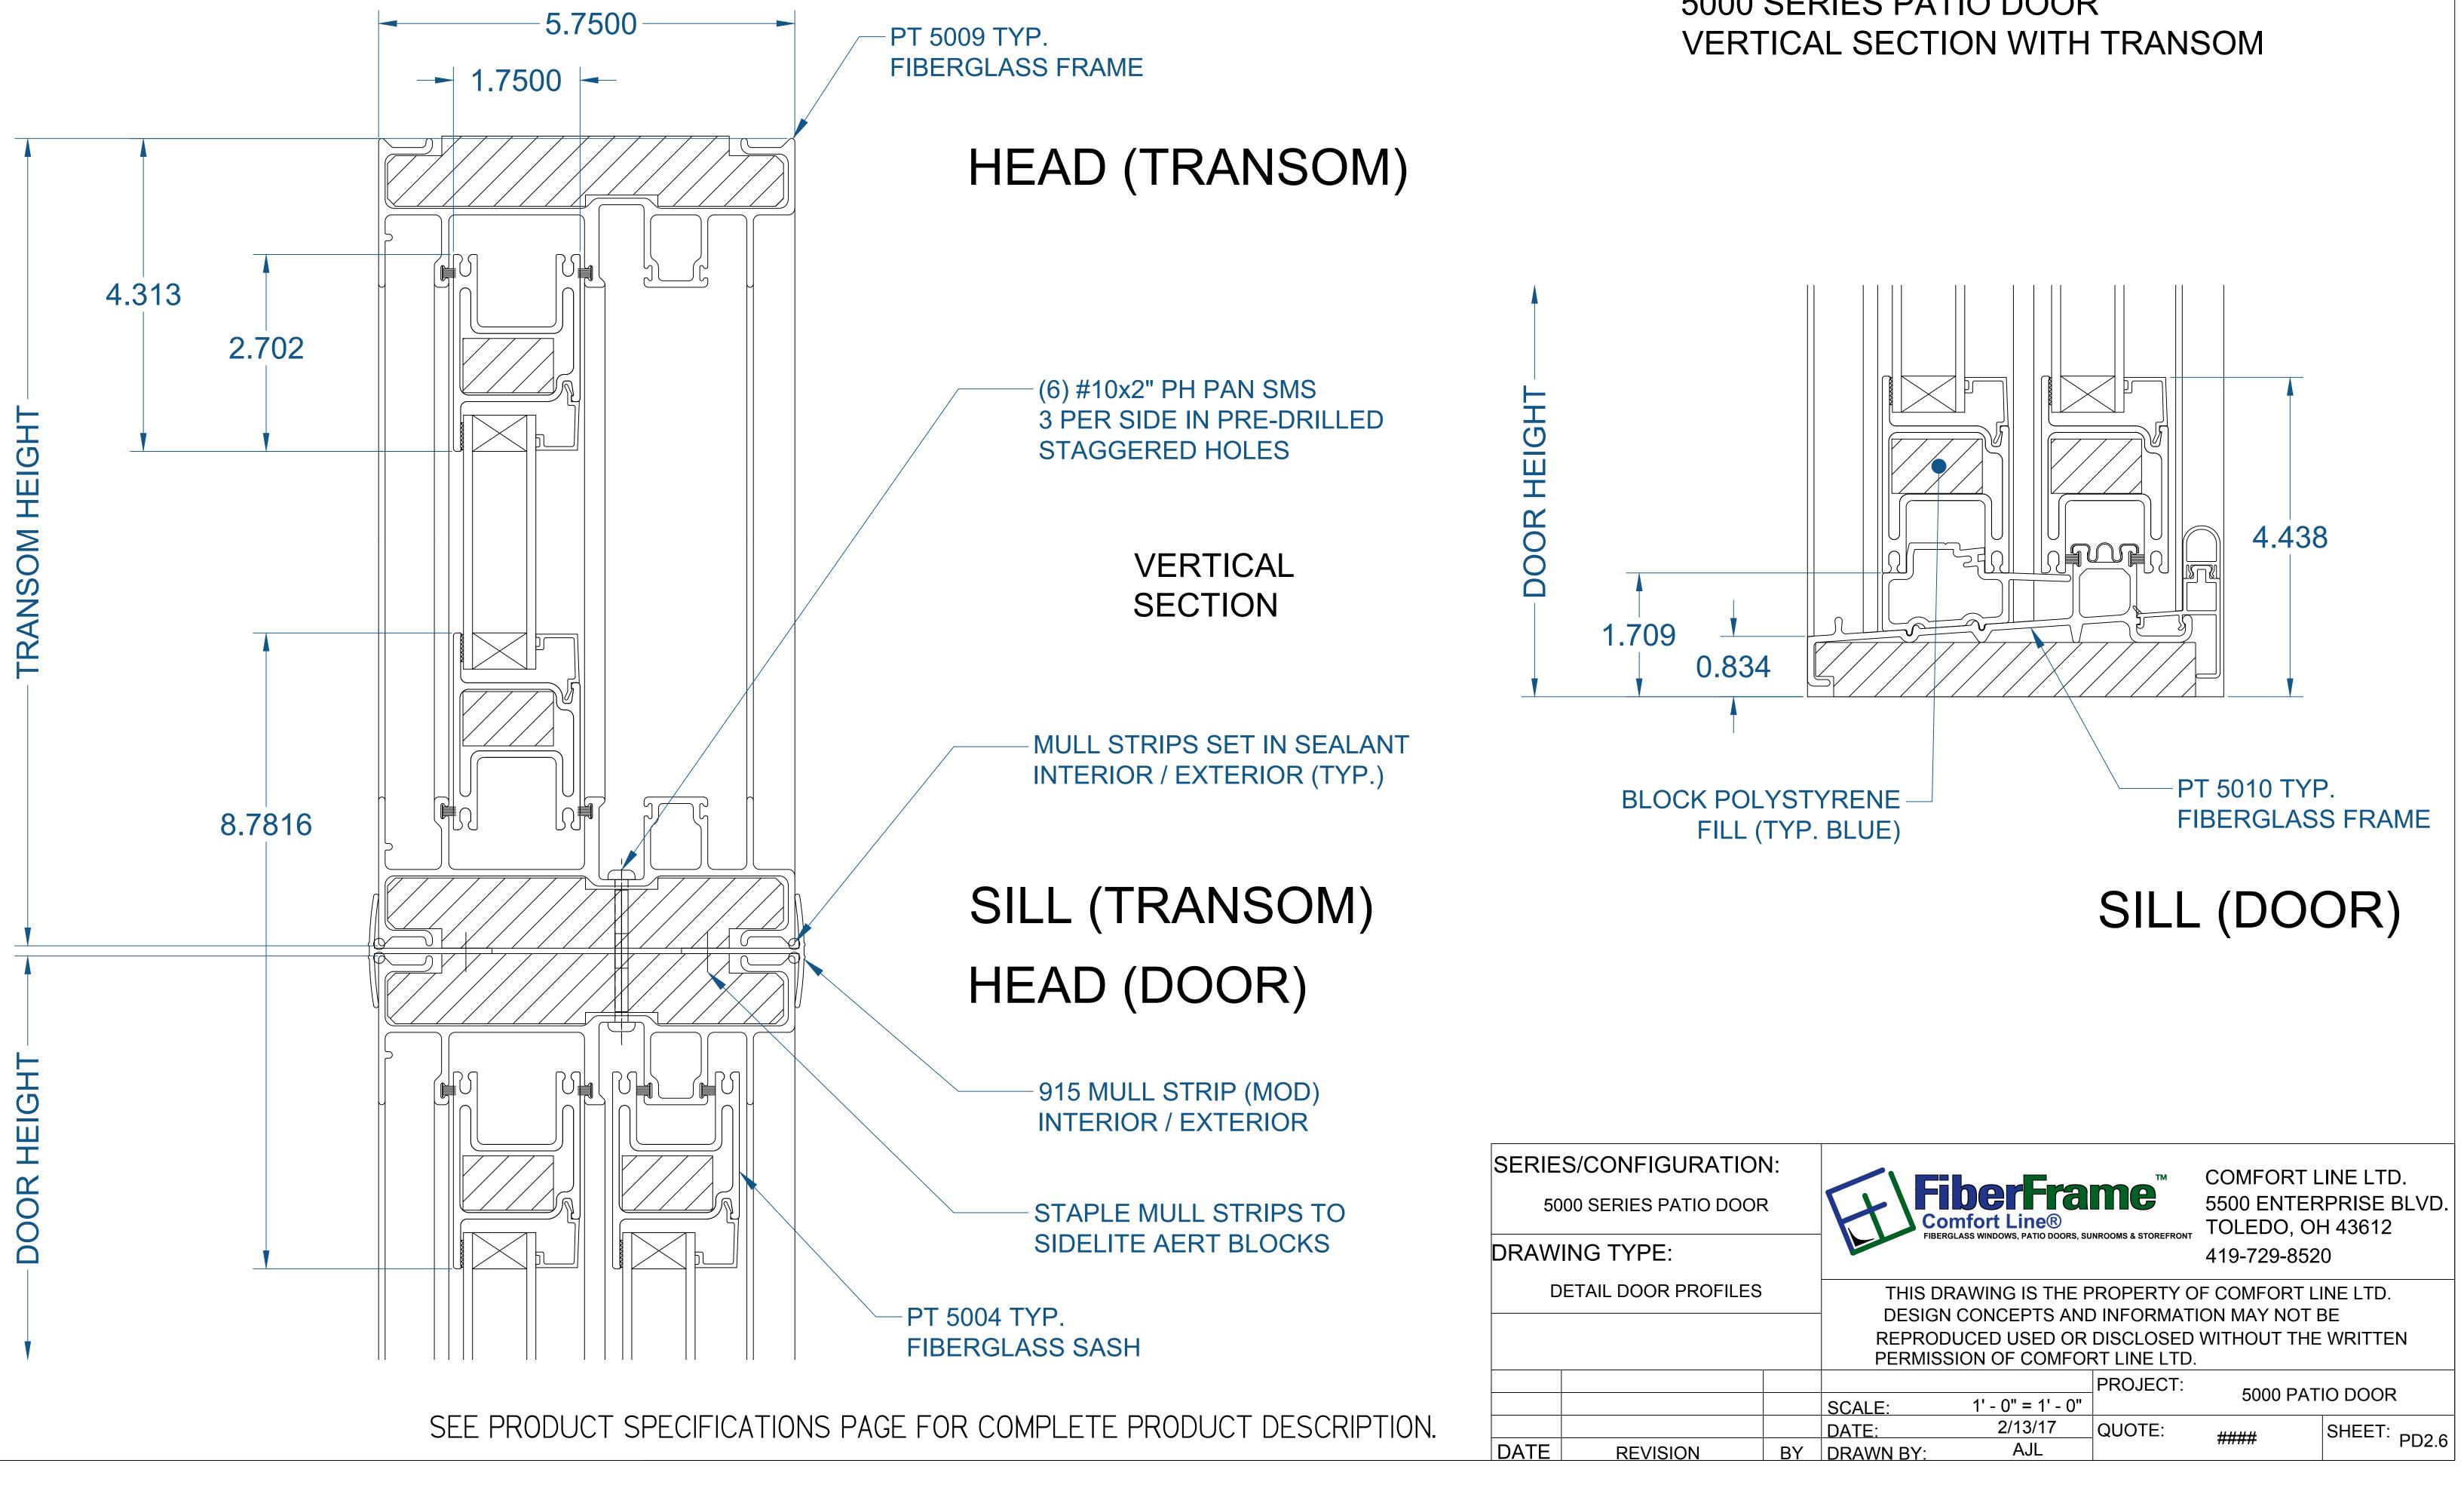




5000 SERIES PATIO DOOR

5000 SERIES PATIO DOOR


(SERIES OVERVIEW)

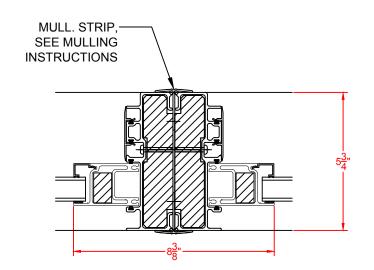



(#

MULL. DETAIL - DOOR / DOOR - TYP. **VERTICAL MULLS**

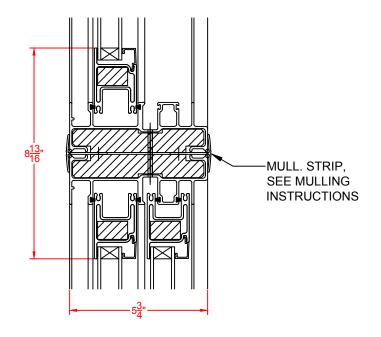

MULL. DETAIL - DOOR / TRANSOM - TYP. HORIZONTAL MULLS


* NOTE:

- ACTUAL INSTALLATION, FASTENERS, ETC. MAY VARY


- ALL SHIMS ARE BY OTHER

SEE PRODUCT SPECIFICATIONS PAGE FOR COMPLETE PRODUCT DESCRIPTION.

(#

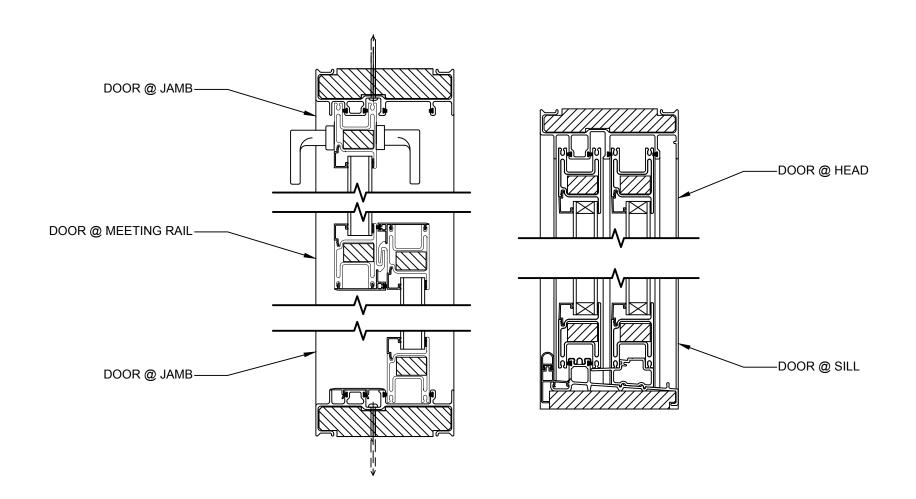


5000 SERIES PATIO DOOR PROFILE W/ **INSTALLATION SCREW**

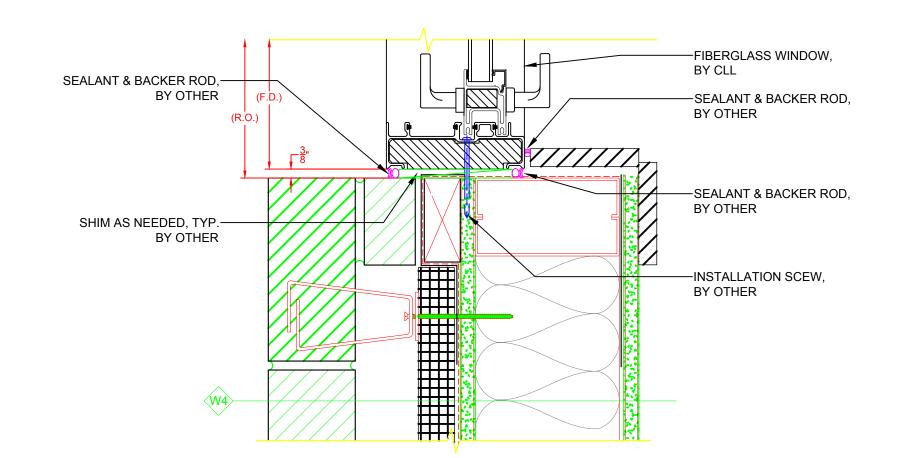




- ALL DRAWINGS ARE FOR REFERENCE PURPOSES ONLY - AVB & SEALANT BY OTHER, PER LOCAL & INTERNATIONAL BUILDING CODES - ALL INSTALLATION SCREWS GOING INTO R.O. ARE BY OTHER

SERIE	S/CONFIGU
50	00 SERIES PAT
DRAW	ING TYPE:
DE	TAIL WINDOW F
DATE	REVISION

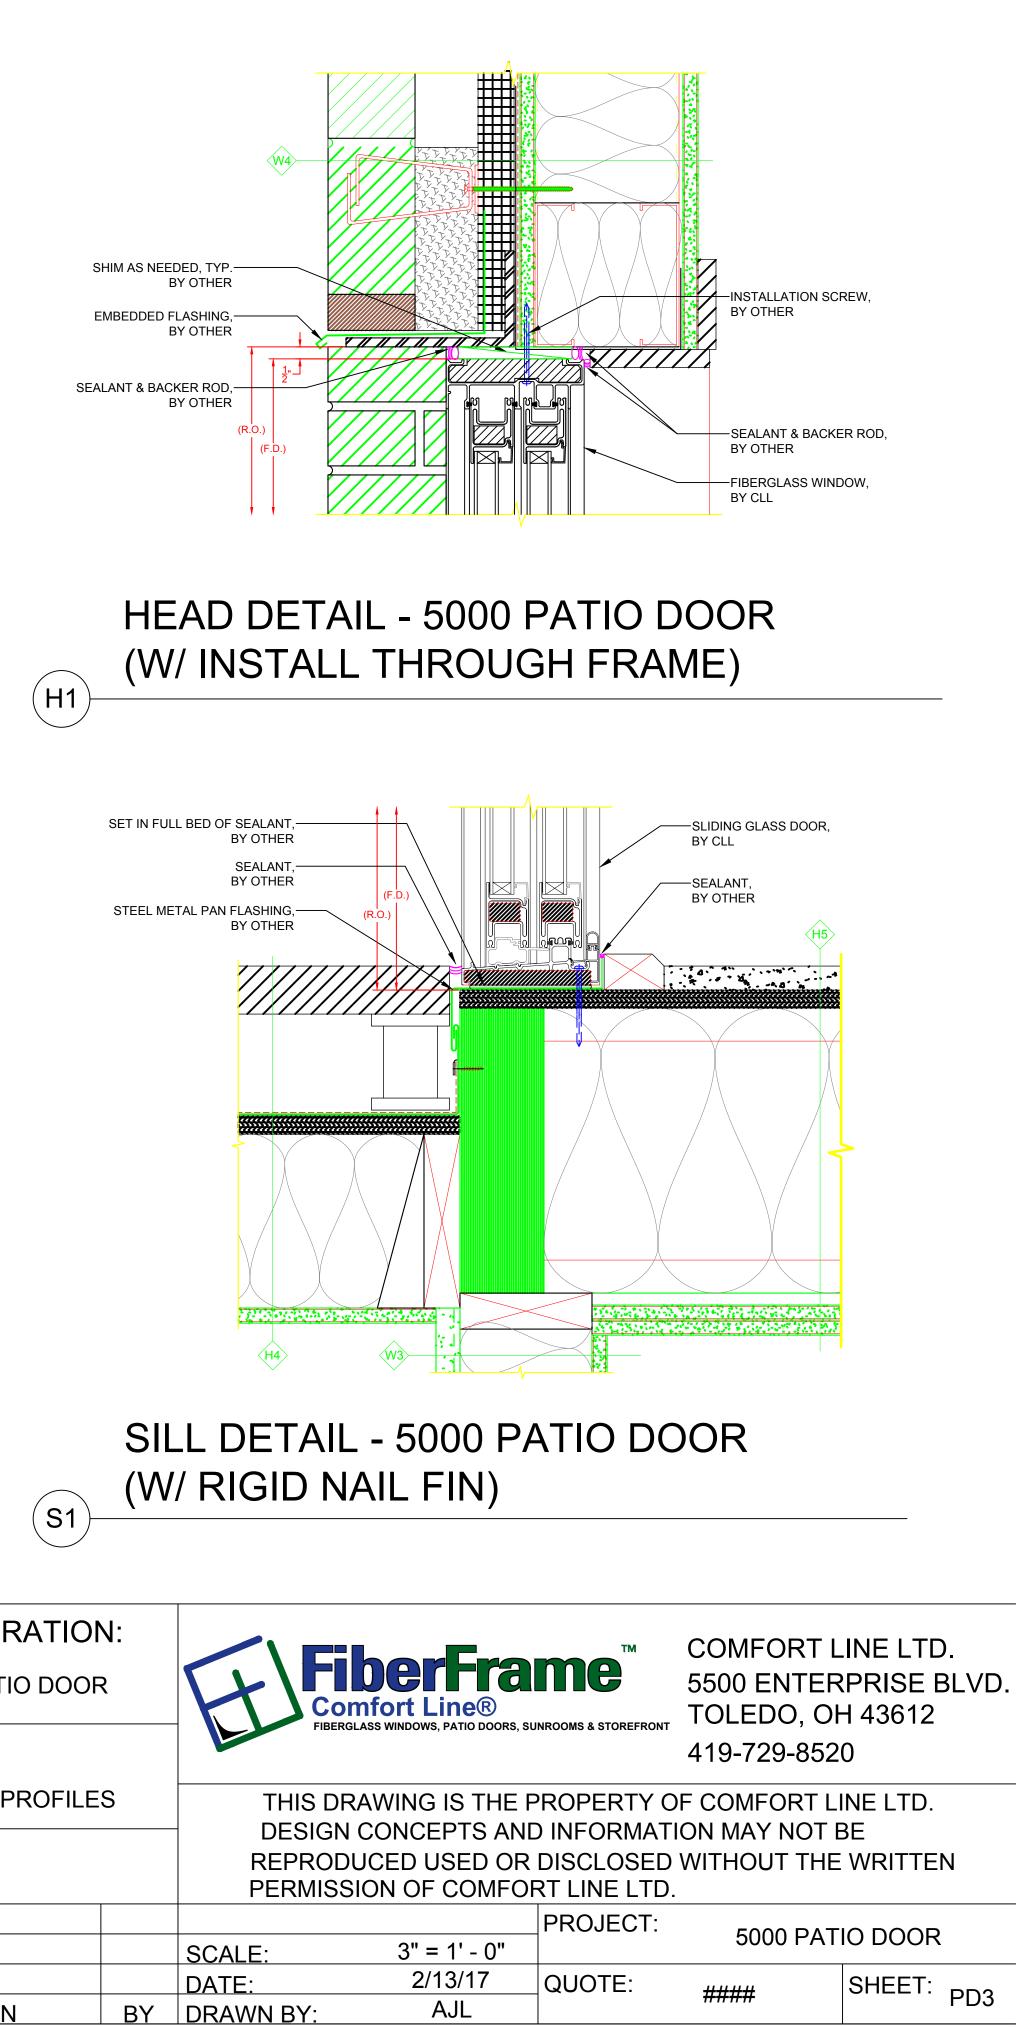


5000 SERIES PATIO DOOR

(INSTALLATION METHODS)

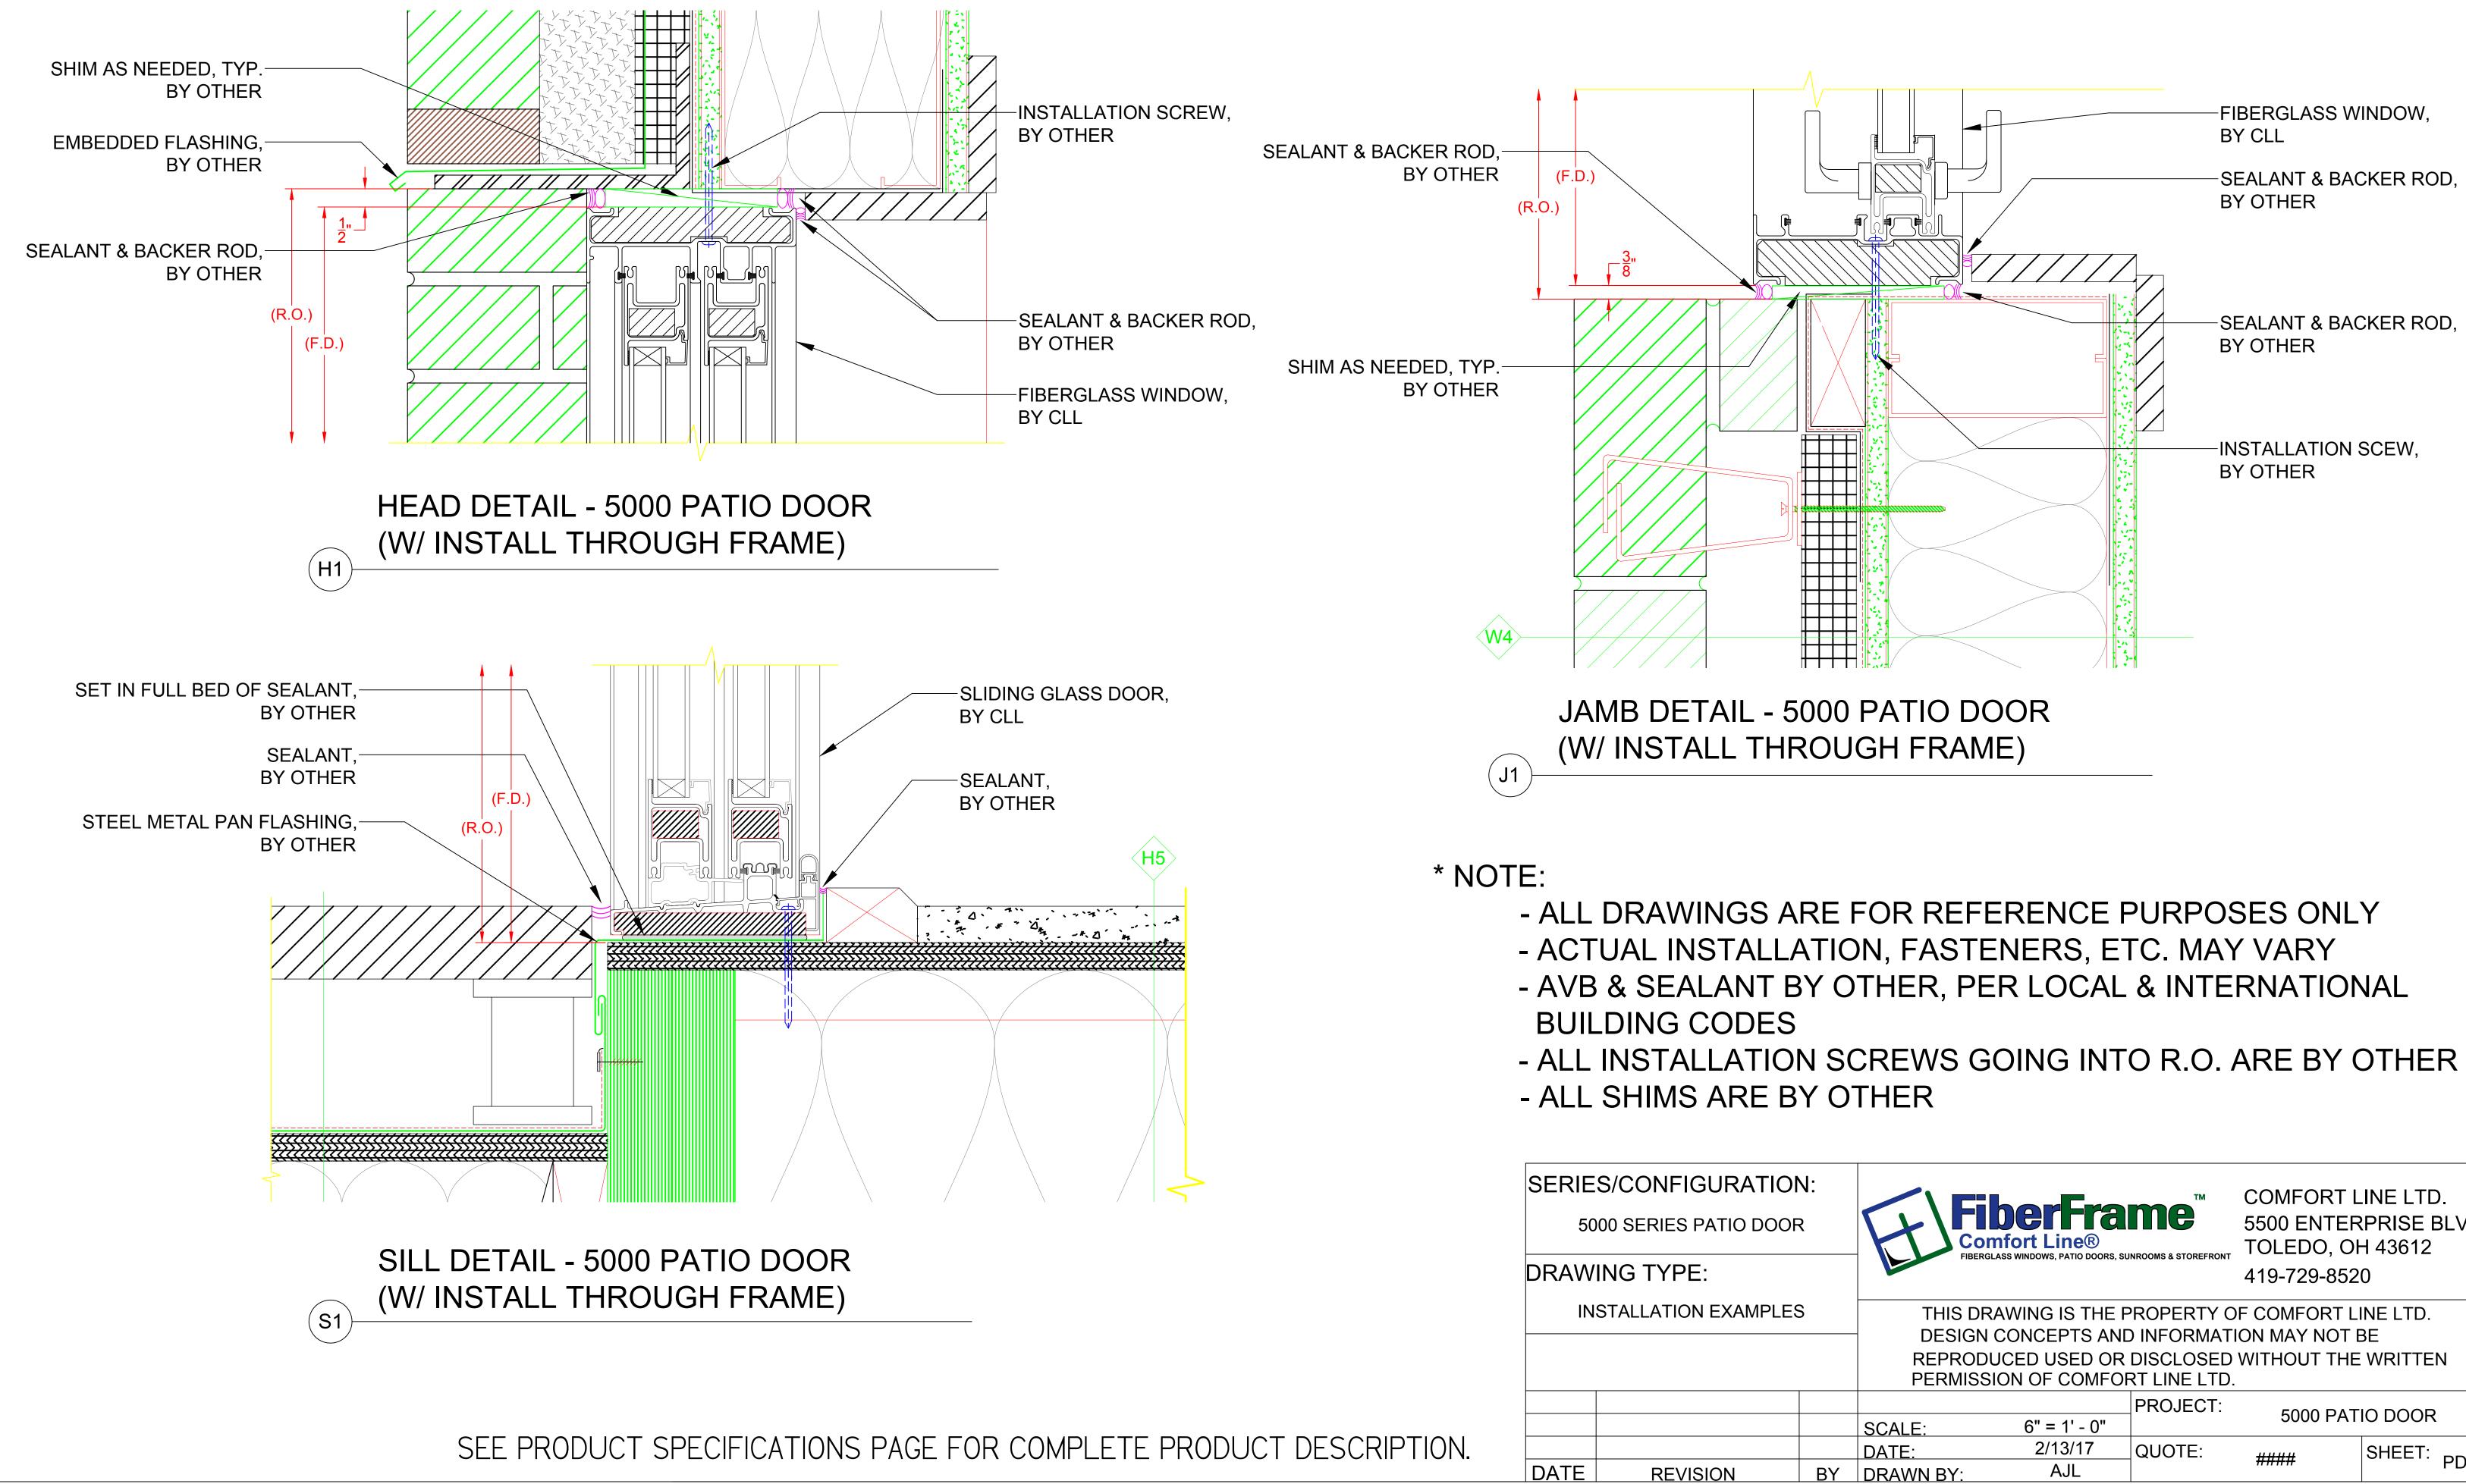


JRATION	N:		_	тм	COMFORT L	.INE LTD.	
TIO DOOR		Com	DerFra fort Line®		5500 ENTERPRISE BLVD. TOLEDO, OH 43612		
		FIBERGLA	ISS WINDOWS, PATIO DOORS, SC	INROUMS & STOREFRONT	419-729-852	0	
EXAMPLES	5	THIS DRAWING IS THE PROPERTY OF COMFORT LINE LTD. DESIGN CONCEPTS AND INFORMATION MAY NOT BE					
		REPRODU	CED USED OR	DISCLOSED			
				PROJECT:	5000 PAT		
		SCALE:	6" = 1' - 0"		3000 T A T		
		DATE:	2/13/17	QUOTE:	####	SHEET: PD4	
NC	BY	DRAWN BY:	AJL			PD4	


5000 SERIES PATIO DOOR (MULLING DETAIL)

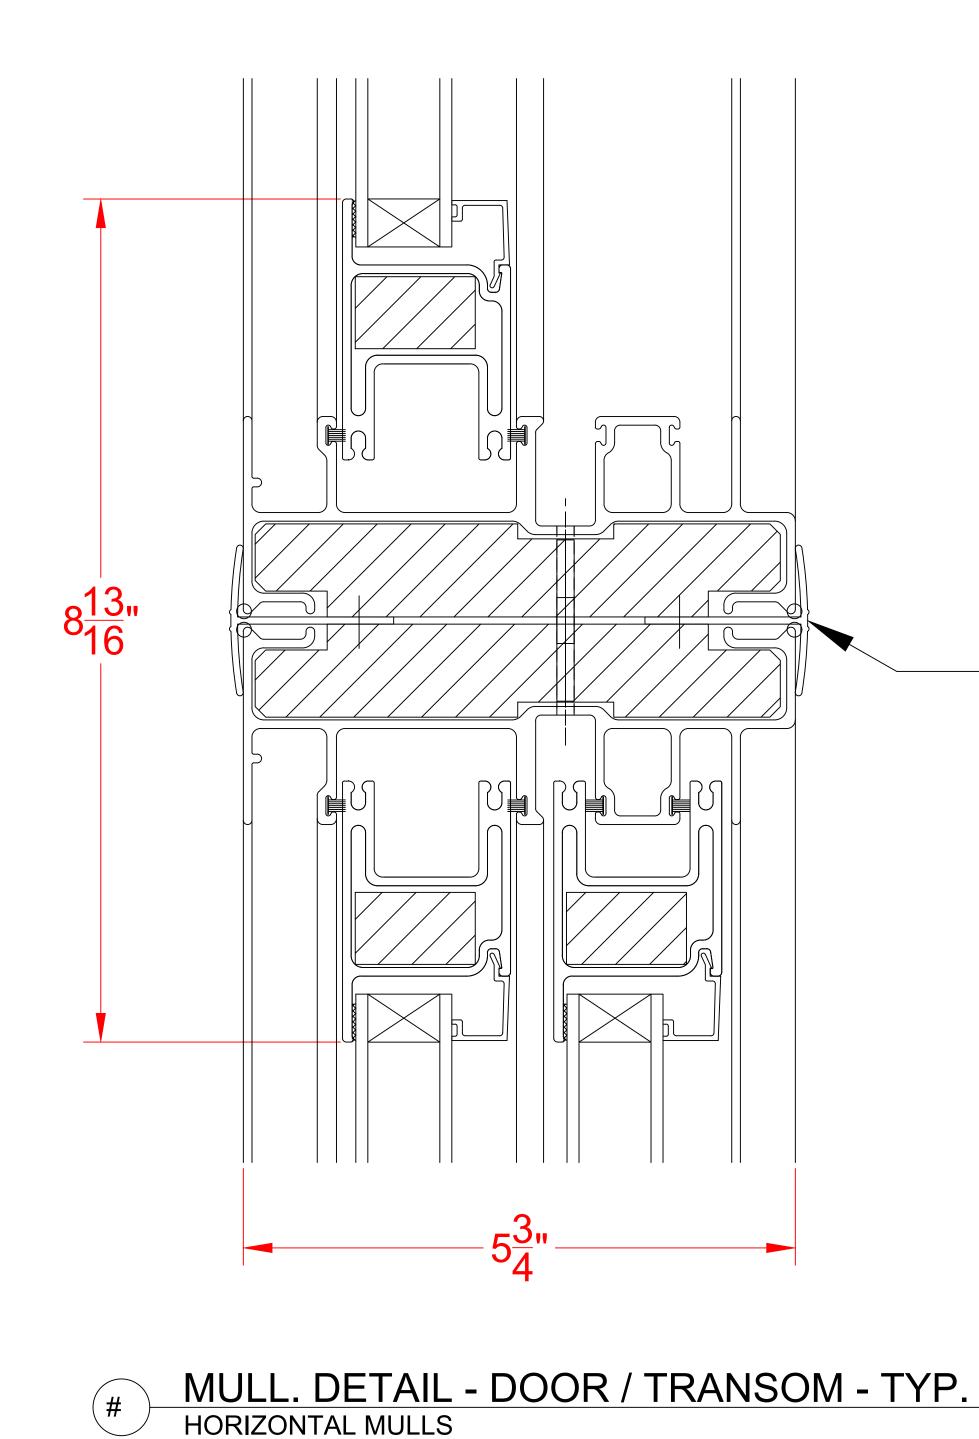

SEE PRODUCT SPECIFICATIONS PAGE FOR COMPLETE PRODUCT DESCRIPTION.

MULL. STRIP, SEE MULLING INSTRUCTIONS

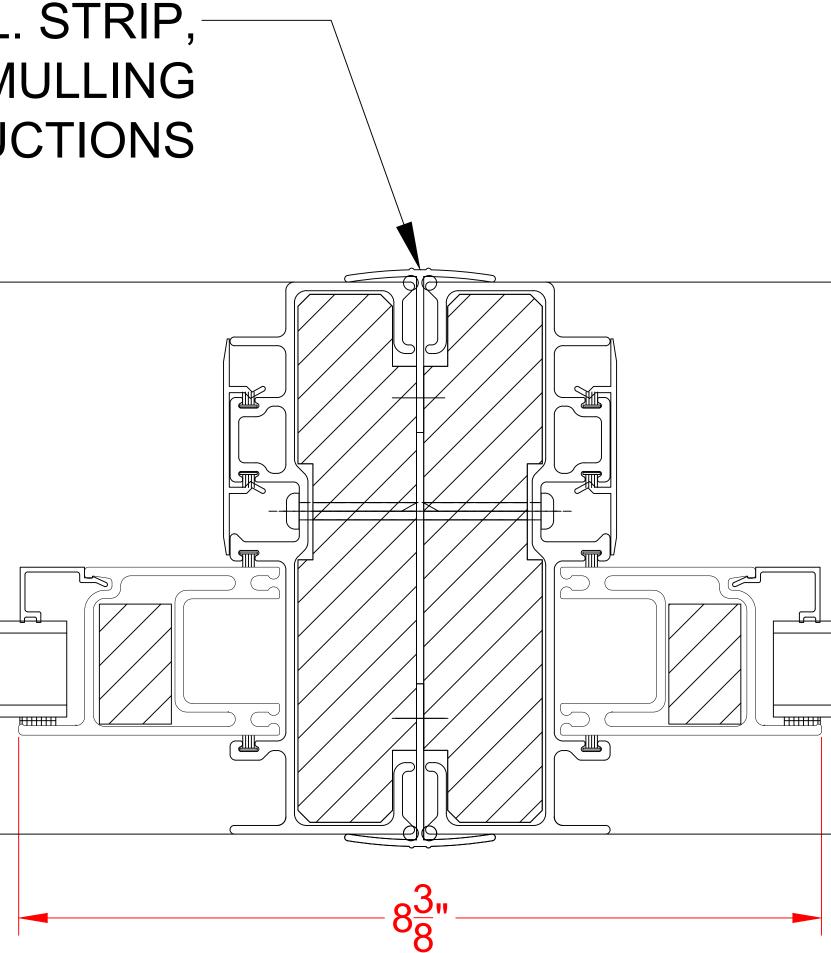

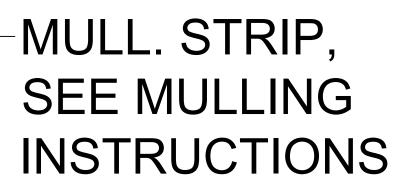

(# VERTICAL MULLS

SERIES/CONFIGUE 5000 SERIES PAT DRAWING TYPE: MULLING SECTIO DATE REVISION

MULLING OPTIONS INCLUDE: 5000 SERIES DOORS 5000 SERIES TRANSOMS

MULL. DETAIL - DOOR / DOOR - TYP.

JRATION	N:			тм	COMFORT L	.INE LTD.		
TIO DOOF	र	FiberFrame Comfort Line®			5500 ENTERPRISE BLVD TOLEDO, OH 43612			
		FIBERGL	ASS WINDOWS, PATIO DOORS, SL	INROOMS & STOREFRONT	419-729-8520			
ON DETAII	L	THIS DRAWING IS THE PROPERTY OF COMFORT LINE LTD.						
		DESIGN CONCEPTS AND INFORMATION MAY NOT BE						
		REPRODUCED USED OR DISCLOSED WITHOUT THE WRITTEN						
		PERMISS	ION OF COMFO	RT LINE LTD.				
				PROJECT:				
		SCALE:	6" = 1' - 0"		5000 PAT	IU DUUR		
		DATE:	2/13/17	QUOTE:	####	SHEET: DDC		
DN	BY	DRAWN BY:	AJL		******	PD5		

5<u>3</u>'